

AMENDMENT OF SOLICITATION/MODIFICATION OF CONTRACT			1. CONTRACT ID CODE	PAGE OF PAGES
2. AMENDMENT/MODIFICATION NO. 0001	3. EFFECTIVE DATE 02-Jun-2015	4. REQUISITION/PURCHASE REQ. NO. ACQR3894253		5. PROJECT NO.(If applicable) 1 4
6. ISSUED BY NAVFAC MID ATLANTIC PWD PENNSYLVANIA 306 MARKET ST., STE #1 ROME NY 13441-4610	CODE N40085	7. ADMINISTERED BY (If other than item 6) See Item 6		
8. NAME AND ADDRESS OF CONTRACTOR (No., Street, County, State and Zip Code)		X	9A. AMENDMENT OF SOLICITATION NO. N40085-15-Q-7610	
		X	9B. DATED (SEE ITEM 11) 06-May-2015	
			10A. MOD. OF CONTRACT/ORDER NO.	
			10B. DATED (SEE ITEM 13)	
CODE	FACILITY CODE			
11. THIS ITEM ONLY APPLIES TO AMENDMENTS OF SOLICITATIONS				
<input checked="" type="checkbox"/> The above numbered solicitation is amended as set forth in Item 14. The hour and date specified for receipt of offer <input checked="" type="checkbox"/> is extended, <input type="checkbox"/> is not extended.				
Offer must acknowledge receipt of this amendment prior to the hour and date specified in the solicitation or as amended by one of the following methods: (a) By completing Items 8 and 15, and returning <u>1</u> copies of the amendment; (b) By acknowledging receipt of this amendment on each copy of the offer submitted; or (c) By separate letter or telegram which includes a reference to the solicitation and amendment numbers. FAILURE OF YOUR ACKNOWLEDGMENT TO BE RECEIVED AT THE PLACE DESIGNATED FOR THE RECEIPT OF OFFERS PRIOR TO THE HOUR AND DATE SPECIFIED MAY RESULT IN REJECTION OF YOUR OFFER. If by virtue of this amendment you desire to change an offer already submitted, such change may be made by telegram or letter, provided each telegram or letter makes reference to the solicitation and this amendment, and is received prior to the opening hour and date specified.				
12. ACCOUNTING AND APPROPRIATION DATA (If required)				
13. THIS ITEM APPLIES ONLY TO MODIFICATIONS OF CONTRACTS/ORDERS. IT MODIFIES THE CONTRACT/ORDER NO. AS DESCRIBED IN ITEM 14.				
A. THIS CHANGE ORDER IS ISSUED PURSUANT TO: (Specify authority) THE CHANGES SET FORTH IN ITEM 14 ARE MADE IN THE CONTRACT ORDER NO. IN ITEM 10A.				
B. THE ABOVE NUMBERED CONTRACT/ORDER IS MODIFIED TO REFLECT THE ADMINISTRATIVE CHANGES (such as changes in paying office, appropriation date, etc.) SET FORTH IN ITEM 14, PURSUANT TO THE AUTHORITY OF FAR 43.103(B).				
C. THIS SUPPLEMENTAL AGREEMENT IS ENTERED INTO PURSUANT TO AUTHORITY OF:				
D. OTHER (Specify type of modification and authority)				
E. IMPORTANT: Contractor <input type="checkbox"/> is not, <input type="checkbox"/> is required to sign this document and return _____ copies to the issuing office.				
14. DESCRIPTION OF AMENDMENT/MODIFICATION (Organized by UCF section headings, including solicitation/contract subject matter where feasible.) N40085-15-Q-7610, Relocate Fire Alarm Devices, Bldg. 311, Naval Support Activity (NSA), Mechanicsburg, PA 1. The purpose of this amendment is to provide answers to Request for Information received. Questions and responses are attached on Page 2. 2. Date for receipt of quotations is hereby changed from 5 June 2015 at 3:00 PM EST to read 9 June 2015 at 3:00 PM EST.				
Except as provided herein, all terms and conditions of the document referenced in Item 9A or 10A, as heretofore changed, remains unchanged and in full force and effect.				
15A. NAME AND TITLE OF SIGNER (Type or print)		16A. NAME AND TITLE OF CONTRACTING OFFICER (Type or print) CHRISTINE SHOLTZ / CONTRACT SPECIALIST ROME, NY TEL: (315) 709-5273 EMAIL: christine.sholtz@navy.mil		
15B. CONTRACTOR/OFFEROR (Signature of person authorized to sign)	15C. DATE SIGNED	16B. UNITED STATES OF AMERICA BY _____ (Signature of Contracting Officer)	16C. DATE SIGNED 02-Jun-2015	

SECTION SF 30 BLOCK 14 CONTINUATION PAGE

SUMMARY OF CHANGES

SECTION SF 30 - BLOCK 14 CONTINUATION PAGE

The following have been added by full text:

QUESTIONS/RESPONSES

Questions/Responses:

1. Would it be possible for me to get catalog cuts and or descriptive data on the equipment (NAC panels, Main panel, and the alarm devises) used for this project? I also would like to know the wire specifications as well as a one line diagram for the work performed in Phase A.
RESPONSE: No catalog cuts or descriptive data on the equipment is available. Contractor shall comply with all fire alarm codes to determine wire specifications.
2. For clarification purposes, two additional drawings (no. 12684741 and 12684742) are attached for additional information as necessary.

(End of Summary of Changes)

PROJECT TITLE AT NAVAL SUPPORT ACTIVITY MECHANICSBURG, PENNSYLVANIA

NAVAL FACILITIES ENGINEERING COMMAND,
MID ATLANTIC

NOT REVIEWED
 APPROVED
 APPROVED AS NOTED
 DISAPPROVED

SUBJECT TO THE REQUIREMENTS OF CONTRACT APPROVAL OF SUBMITTAL DOES NOT INCLUDE APPROVAL OF ANY DEVIATION FROM CONTRACT REQUIREMENTS UNLESS CONTRACTOR CALLS ATTENTION TO & SUPPORTS THE DEVIATION CONTRACTOR SHALL BE RESPONSIBLE FOR PROVIDING PROPER PHYSICAL DIMENSIONS & WEIGHTS, TRADES, COORDINATION, ETC., AS REQUIRED.

REVIEWER/CODE: **MATT LAUVER, P.E., CI45**
DATE: **10FEB2015**
FOR OFFICER IN CHARGE OF CONSTRUCTION

DRAWING REVISION #1 - 2/7/2015
DATE: 2/7 DAW

LEGEND

- XXCD STROBE VISUAL FIRE ALARM NOTIFICATION (WALL MOUNTED)
- XXCD STROBE VISUAL FIRE ALARM NOTIFICATION (CEILING MOUNTED)
- XXCD BELL/STROBE AUDIBLE AND VISUAL FIRE ALARM NOTIFICATION COMBINATION
- F PULL STATION MANUAL FIRE ALARM NOTIFICATION DEVICE.


NOTES

- 1 CONTRACTOR SHALL FIELD VERIFY EXISTING CANDELA RATINGS OF ALL FIRE ALARM DEVICES. IF CANDELA RATING IS NOT SUFFICIENT, CONTRACTOR SHALL SIZE THE DEVICE ACCORDING TO THE COVERAGE ZONE AREA. CONTRACTOR SHALL RELOCATE EXISTING DEVICES IF POSSIBLE. NEW DEVICES MAY BE REQUIRED IN SOME INSTANCES.
- 2 CONTRACTOR SHALL INSTALL NAC PANEL, IN THIS GENERAL LOCATION, TO SERVE NEW FIRE ALARM DEVICES. CONTRACTOR SHALL PROVIDE BATTERY AND VOLTAGE DROP CALCULATIONS TO THE SITE FOR REVIEW.
- 3 REPLACE EXISTING STROBE WITH 15CD STROBE.
- 4 NEW DEVICE. DEVICE SHALL BE LOCATED TO A HEIGHT ABOVE FURNITURE WALLS (IF APPLICABLE) TO ILLUMINATE ZONE.
- 5 REMOVE DEVICE. DEVICE SHALL BE PROTECTED AND STORED FOR FUTURE USE.
- 6 EXISTING FIRE ALARM DEVICE SHALL BE RELOCATED TO A HEIGHT ABOVE NEW FURNITURE WALLS TO ILLUMINATE ZONE. CEILING MOUNT WHERE POSSIBLE. REUSE EXISTING FEED.
- 7 RELOCATE EXISTING DEVICE TO CEILING.
- 8 REPLACE EXISTING STROBE WITH 30CD STROBE.


NOTE:

IF THERE IS A QUESTION ABOUT A HAZARDOUS MATERIAL/ASBESTOS CONTAINING MATERIAL ENCOUNTERED DURING THE COURSE OF WORK THAT IS NOT IDENTIFIED ON THE DRAWINGS, THE CONTRACTOR WILL STOP WORK IMMEDIATELY AND CONTACT THE CONTRACTING OFFICER WHO IS TO MAKE A DETERMINATION IF THE MATERIAL IS HAZARDOUS.

SEE SHEET FP-2

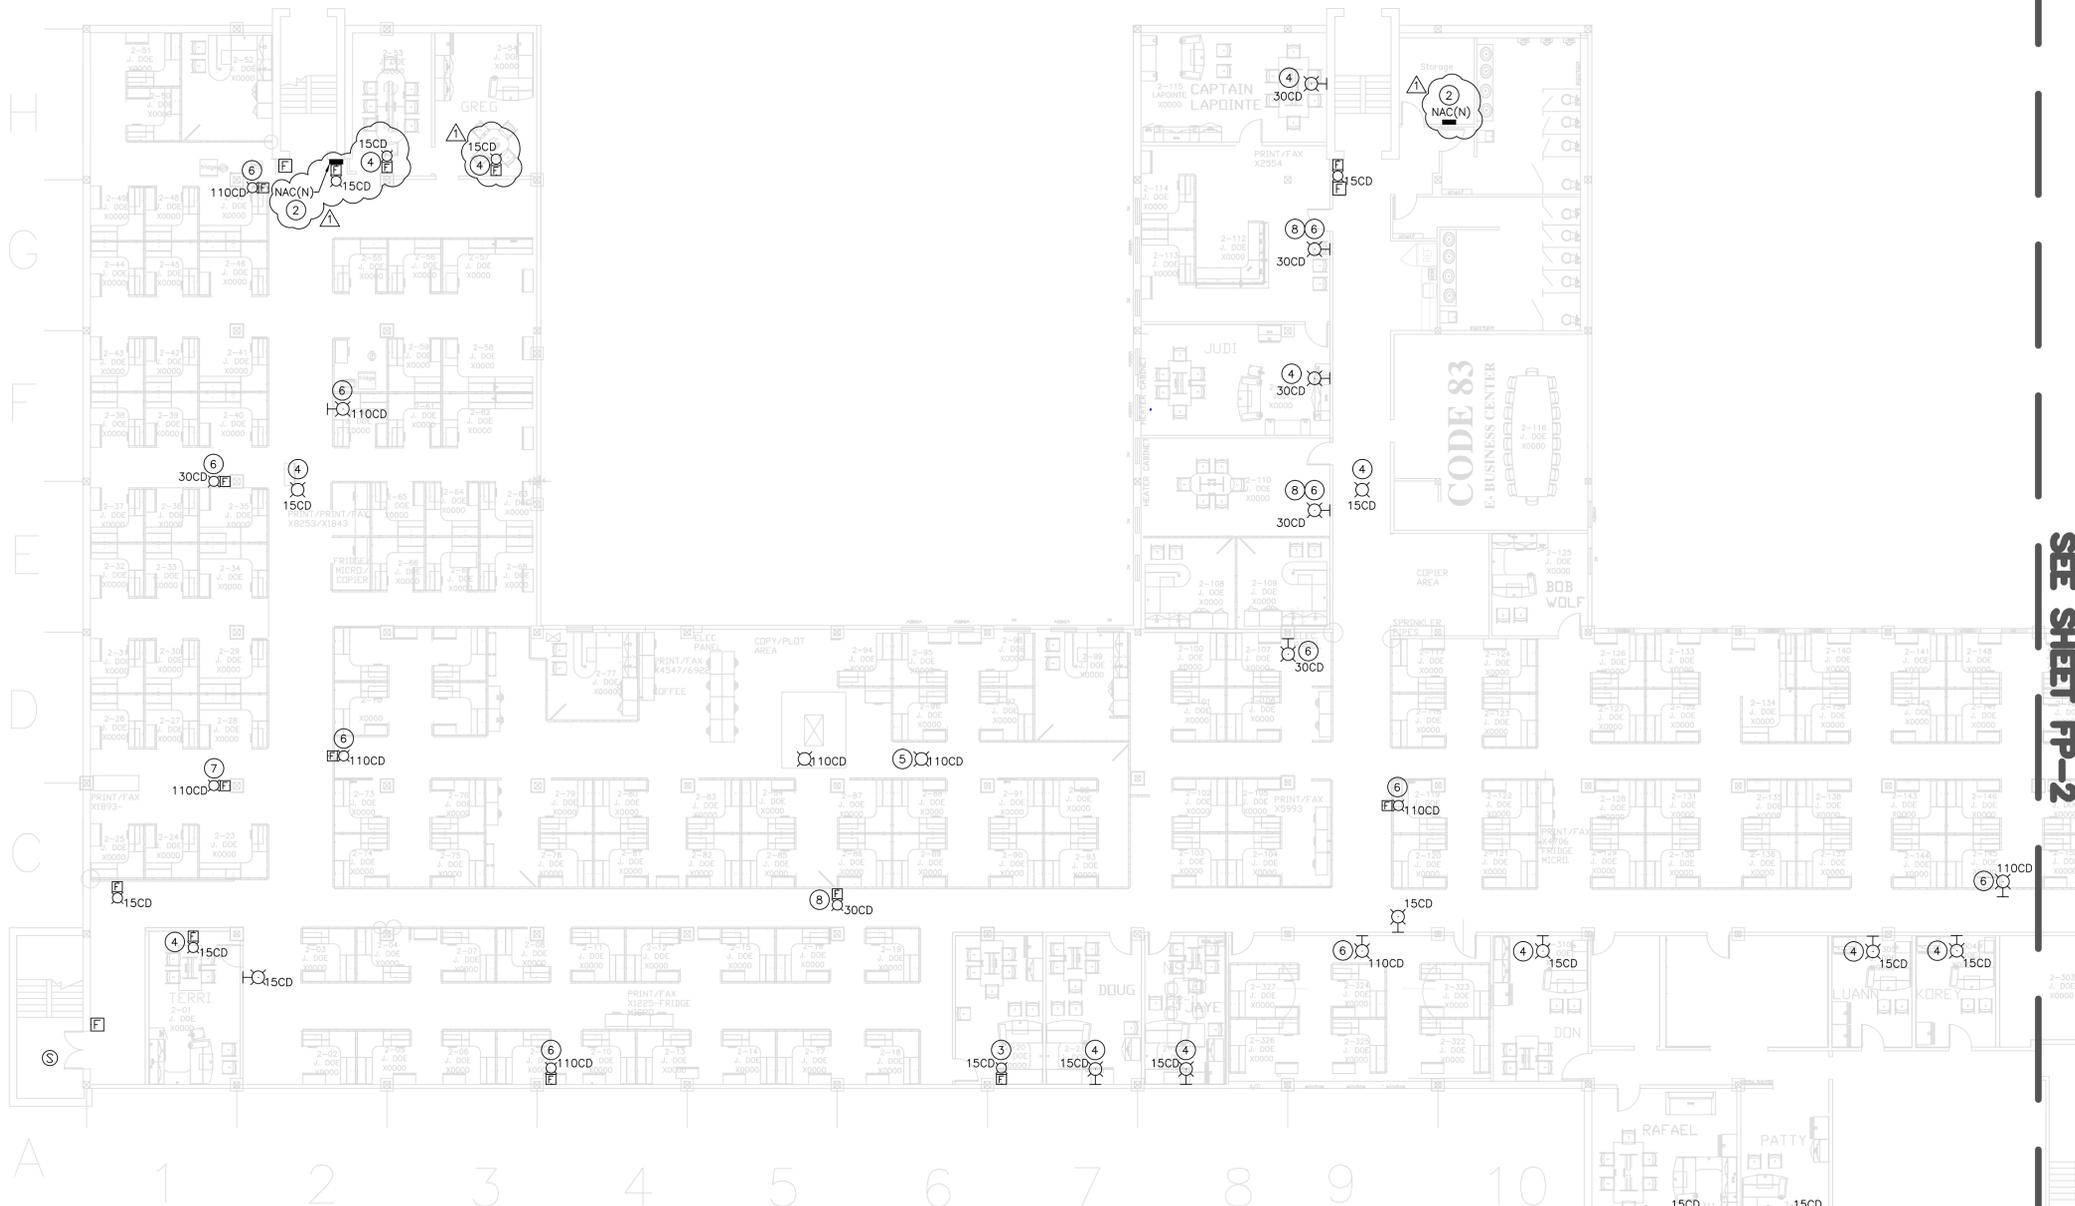

BUILDING 311 - SECOND FLOOR FIRE ALARM DRAWING
SCALE: 3/32" = 1'-0"

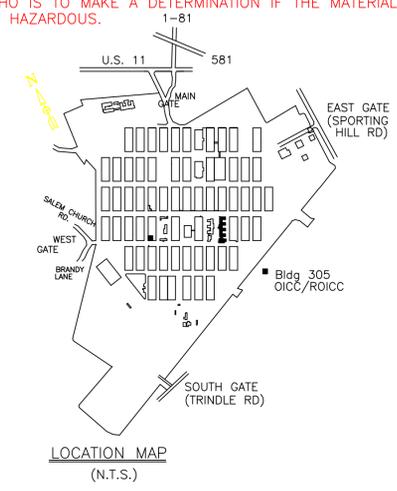

APPROVED:	DATE:	PWO, DWG. NO. PWD
XXX	xx/xx/xx	DESIGNED DAW
OFFICER IN CHARGE		DRAWN DAW
REVIEWED BY: XXX	DATE:	CHKD
	xx/xx/xx	
ENVIRON:		HD ARCH:
		HD STRU:
FIRE DEPT. XXX		HD CIVIL:
		HD ELEC:
		HD MECH:
SAFETY		
SATISFACTORY TO:	SATISFACTORY TO:	
TENANT	DIRECTOR OF DESIGN	DATE: 12/05/14

NAVAL FACILITIES ENGINEERING COMMAND
MID-ATLANTIC
NAVAL SUPPORT ACTIVITY - MECHANICSBURG, PA

DEPARTMENT OF THE NAVY
NAVAL FACILITIES ENGINEERING COMMAND - MID-ATLANTIC
NAVAL SUPPORT ACTIVITY - MECHANICSBURG, PA

DESIGNER: []
DESIGNED BY: []
CHECKED BY: []
REVIEWED BY: []
DATE: []

FOR COMMANDER W/AF: []
DATE: []

DES: []
DIR: []

DESIGNER: []
DATE: []

REVIEWED BY: []
DATE: []

AC/EC: []

FIRE PROTECTION: NA

BRANCH MANAGER: []

DESIGN DIRECTOR: []

NAVFAC DRAWING NO. 12684741
SHEET 1 OF 2

PROJECT TITLE

AT NAVAL SUPPORT ACTIVITY

MECHANICSBURG, PENNSYLVANIA

NAVAL FACILITIES ENGINEERING COMMAND,
MID ATLANTIC

NOT REVIEWED
 APPROVED
 APPROVED AS NOTED
 DISAPPROVED

SUBJECT TO THE REQUIREMENTS OF CONTRACT APPROVAL OF SUBMITTAL DOES NOT INCLUDE APPROVAL OF ANY DEVIATION FROM CONTRACT REQUIREMENTS UNLESS CONTRACTOR CALLS ATTENTION TO & SUPPORTS THE DEVIATION CONTRACTOR SHALL BE RESPONSIBLE FOR PROVIDING PROPER PHYSICAL DIMENSIONS & WEIGHTS, TRADES, COORDINATION, ETC., AS REQUIRED.

REVIEWER/CODE: **MATT LAUVER, P.E., CI45**
DATE: **10FEB2015**
FOR OFFICER IN CHARGE OF CONSTRUCTION

DRAWING REVISION #1 - 2/7/2015
DATE: 2/7/2015
DAW

- #### LEGEND
- XXCD STROBE VISUAL FIRE ALARM NOTIFICATION (WALL MOUNTED)
 - XXCD STROBE VISUAL FIRE ALARM NOTIFICATION (CEILING MOUNTED)
 - XXCD BELL/STROBE AUDIBLE AND VISUAL FIRE ALARM NOTIFICATION COMBINATION
 - E PULL STATION MANUAL FIRE ALARM NOTIFICATION DEVICE.

- #### NOTES
- CONTRACTOR SHALL FIELD VERIFY EXISTING CANDELA RATINGS OF ALL FIRE ALARM DEVICES. IF CANDELA RATING IS NOT SUFFICIENT, CONTRACTOR SHALL SIZE THE DEVICE ACCORDING TO THE COVERAGE ZONE AREA. CONTRACTOR SHALL RELOCATE EXISTING DEVICES IF POSSIBLE. NEW DEVICES MAY BE REQUIRED IN SOME INSTANCES.
- 1 NOT USED.
 - 2 NOT USED.
 - 3 EXISTING FIRE ALARM DEVICE SHALL BE RELOCATED TO A HEIGHT ABOVE NEW FURNITURE WALLS TO ILLUMINATE ZONE. CEILING MOUNT WHERE POSSIBLE. REUSE EXISTING FEED.
 - 4 NEW DEVICE. DEVICE SHALL BE LOCATED TO A HEIGHT ABOVE FURNITURE WALLS TO ILLUMINATE ZONE.
 - 5 REMOVE DEVICE. DEVICE SHALL BE PROTECTED AND STORED FOR FUTURE USE.

