


BLDG. 484 - NEX MAIN STORE EXPANSION & RENOVATION


SUBBASE NEW LONDON
GROTON, CT

NAVAL FACILITIES ENGINEERING COMMAND ~ NORTHEAST

EPROJECT NO. 1305708
CONSTR. CONTR. NO. N40085-14-C-5203
REVISED FINAL SUBMITTAL
JULY 22, 2014

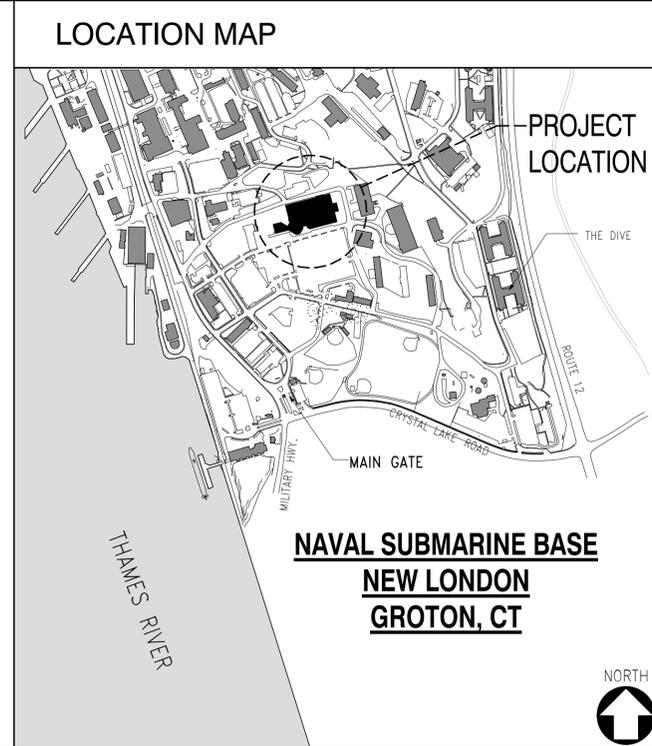

STAGING AREAS

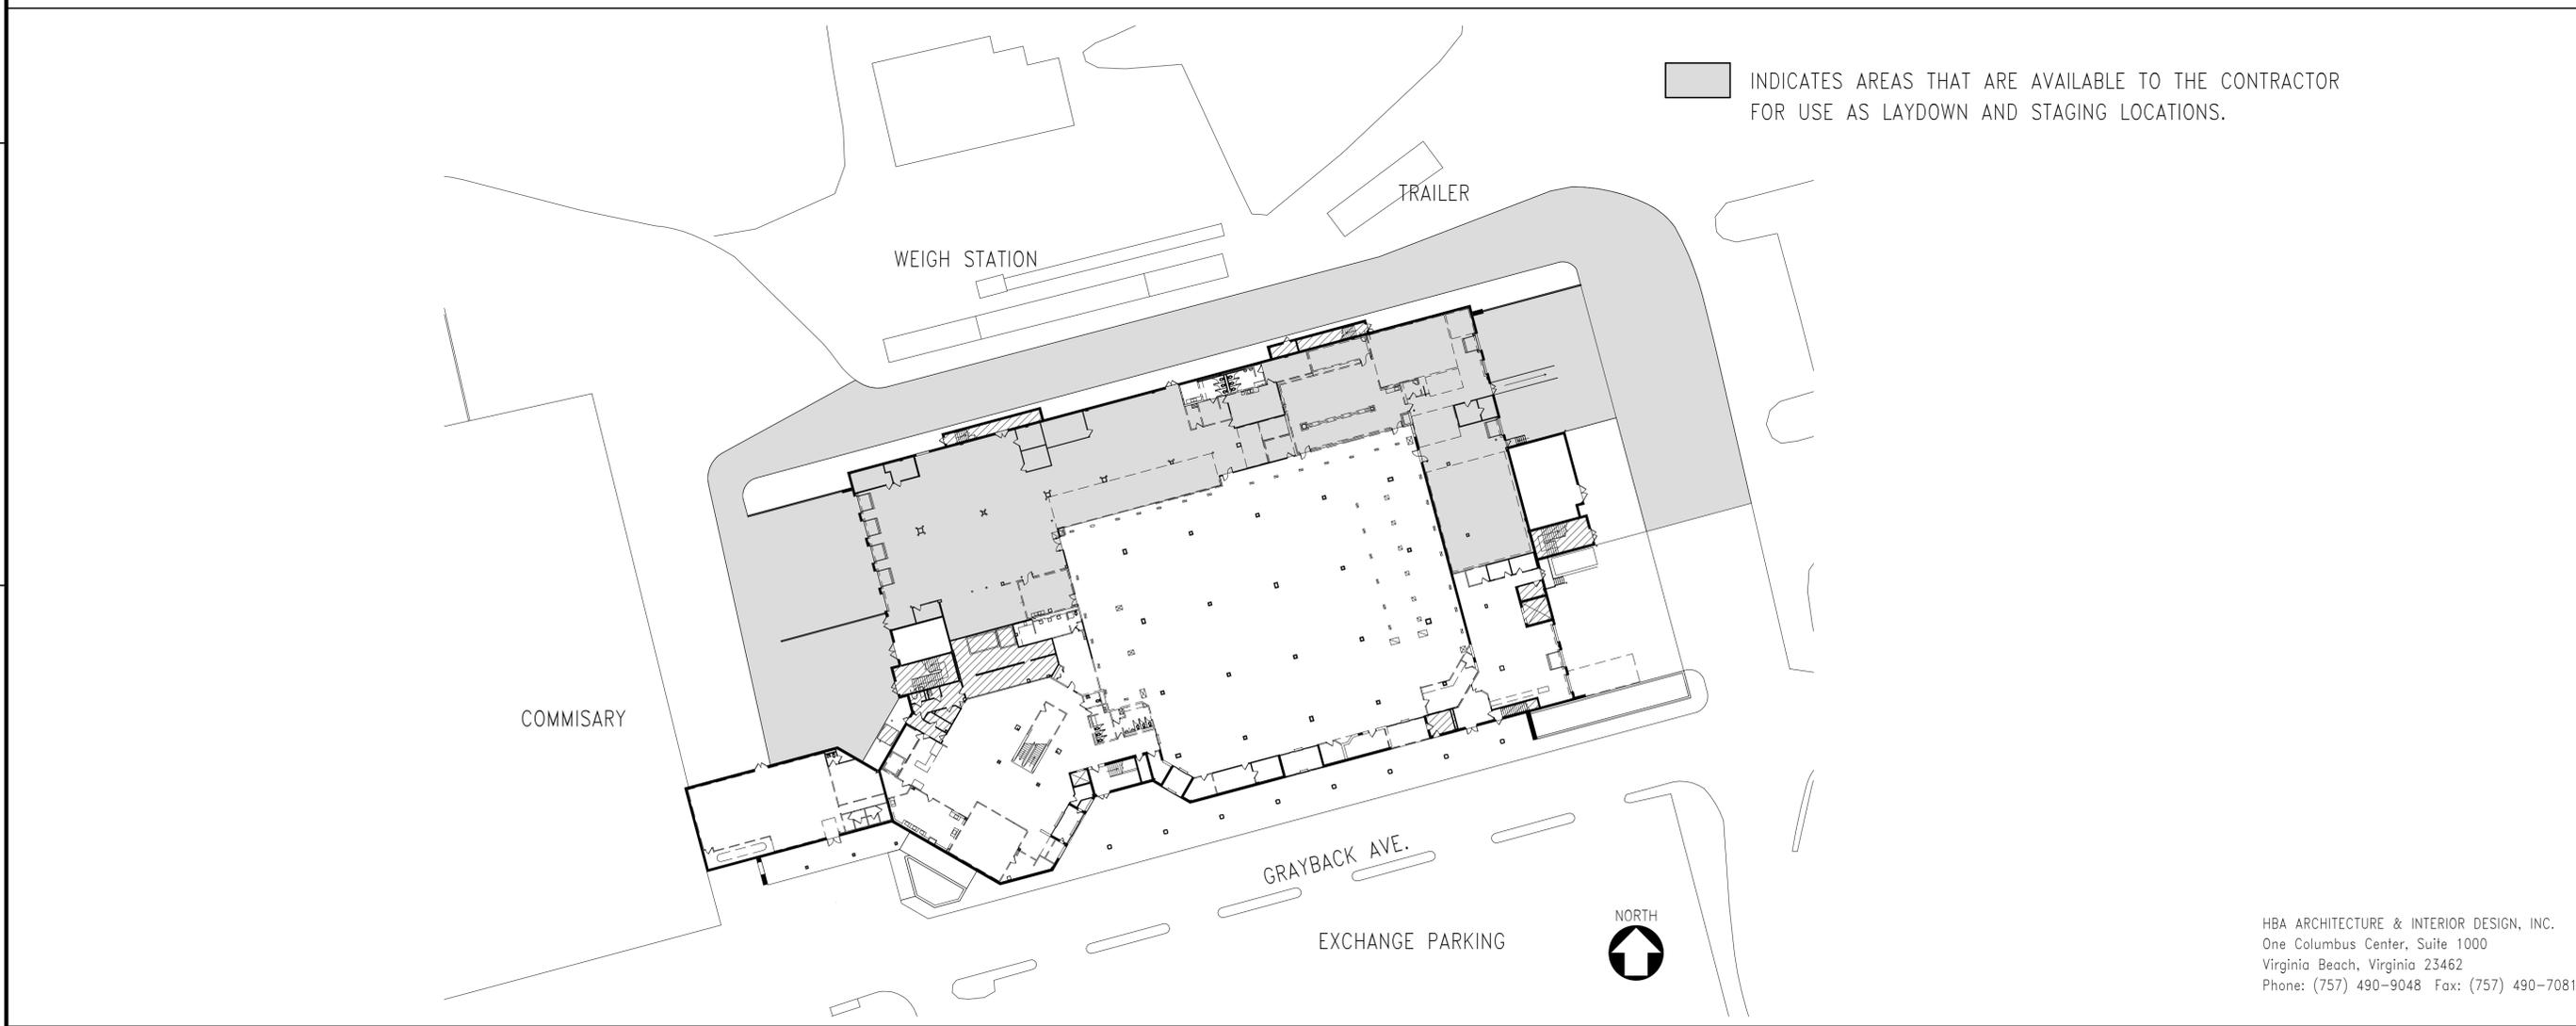

DATE	APPR.
DESCRIPTION	DATE
FOR COMMANDER NAVFAC ACTIVITY CDR MARC BERNATH NEXCOM - FACILITIES DIVISION SATISFACTORY TO DATE 07JUL2014 DES. JB DRW. JT CHK. DE PM/DW RDS/PJB BRANCH MANAGER CHIEF ENG/ARCH DWG FIRE PROTECTION	
DEPARTMENT OF THE NAVY NAVAL FACILITIES ENGINEERING COMMAND NAVAL STATION - NORFOLK, VIRGINIA GROTON, CT BLDG. 484 - NEX MAIN STORE EXPANSION & RENOVATION TITLE SHEET	
SCALE: GRAPHIC	
EPROJECT NO. 1305708	
CONSTR. CONTR. NO. N40085-14-C-5203	
NAVFAC DRAWING NO. 12667645	
SHEET 1 OF 236	
G-001	

HBA ARCHITECTURE & INTERIOR DESIGN, INC.
One Columbus Center, Suite 1000
Virginia Beach, Virginia 23462
Phone: (757) 490-9048 Fax: (757) 490-7081

DRAWING INDEX

SHEET NO.	DRAWING TITLE	NAVFAC NO.	SHEET NO.	DRAWING TITLE	NAVFAC NO.	SHEET NO.	DRAWING TITLE	NAVFAC NO.	SHEET NO.	DRAWING TITLE	NAVFAC NO.
GENERAL			A-402	ENLARGED FLOOR PLANS	12667701	PD105	FIRST FLOOR - DEMOLITION PLAN - AREA 'E'	12667758	E-105	FIRST FLOOR - LIGHTING PLAN - AREA 'E'	12667819
G-001	TITLE SHEET	12667645	A-403	INTERIOR ELEVATIONS	12667702	PD106	SECOND FLOOR PLAN - DEMOLITION PLAN - AREA 'A'	12667759	E-106	SECOND FLOOR - LIGHTING PLAN - AREA 'A'	12667820
G-002	DRAWING INDEX	12667646	A-404	INTERIOR ELEVATIONS	12667703	PD107	SECOND FLOOR PLAN - DEMOLITION PLAN - AREA 'B'	12667760	E-107	SECOND FLOOR - LIGHTING PLAN - AREA 'B'	12667821
G-003	PHASING PLAN - PHASE 1	12667647	A-405	STAIR #1 - ENLARGED PLANS & ELEVATIONS	12667704	PD108	SECOND FLOOR PLAN - DEMOLITION PLAN - AREA 'C'	12667761	E-108	SECOND FLOOR - LIGHTING PLAN - AREA 'C'	12667822
G-004	PHASING PLAN - PHASE 2	12667648	A-501	DOOR DETAILS	12667705	PD109	SECOND FLOOR PLAN - DEMOLITION PLAN - AREA 'D'	12667762	E-109	SECOND FLOOR - LIGHTING PLAN - AREA 'D'	12667823
G-005	PHASING PLAN - PHASE 3	12667649	A-502	DETAILS	12667706	PD401	ENLARGED DEMOLITION PLANS	12667763	E-110	FIRST FLOOR - POWER PLAN - AREA 'A'	12667824
G-006	PHASING PLAN - PHASE 4	12667650	A-503	DETAILS	12667707	PD402	ENLARGED DEMOLITION PLANS	12667764	E-111	FIRST FLOOR - POWER PLAN - AREA 'B'	12667825
G-007	PHASING PLAN - PHASE 5	12667651	A-504	DETAILS	12667708	P-101	FIRST FLOOR PLAN - AREA 'A'	12667765	E-112	FIRST FLOOR - POWER PLAN - AREA 'C'	12667826
LIFE SAFETY			A-505	CASEWORK DETAILS	12667709	P-102	FIRST FLOOR PLAN - AREA 'B'	12667766	E-113	FIRST FLOOR - POWER PLAN - AREA 'D'	12667827
LS001	LIFE SAFETY CODE ANALYSIS	12667652	A-506	CASEWORK DETAILS	12667710	P-103	FIRST FLOOR PLAN - AREA 'D'	12667767	E-114	FIRST FLOOR - POWER PLAN - AREA 'E'	12667828
LS101	LIFE SAFETY FIRST FLOOR PLAN	12667653	A-601	DOOR SCHEDULE	12667711	P-104	FIRST FLOOR PLAN - AREA 'E'	12667768	E-115	SECOND FLOOR - POWER PLAN - AREA 'A'	12667829
LS102	LIFE SAFETY SECOND FLOOR PLAN	12667654	A-602	FINISH SCHEDULE	12667712	P-105	SECOND FLOOR PLAN - AREA 'A'	12667769	E-116	SECOND FLOOR - POWER PLAN - AREA 'B'	12667830
LS103	OCCUPANT LOAD CALCULATION	12667655	AI101	FIRST FLOOR - FURNITURE PLAN - AREA 'A'	12667713	P-401	ENLARGED PLANS	12667770	E-117	SECOND FLOOR - POWER PLAN - AREA 'C'	12667831
HAZMAT			AI102	FIRST FLOOR - FURNITURE PLAN - AREA 'B'	12667714	P-402	ENLARGED BARBER SHOP AND BEAUTY SALON PLAN	12667771	E-118	SECOND FLOOR - POWER PLAN - AREA 'D'	12667832
HM001	HAZARDOUS MATERIAL NOTES & PHOTOGRAPHS	12667656	AI103	FIRST FLOOR - FURNITURE PLAN - AREA 'C'	12667715	P-501	DETAILS	12667772	E-119	ELECTRICAL ROOF PLAN	12667833
HM002	FIRST FLOOR HAZARDOUS MATERIALS REMOVAL PLAN	12667657	AI104	FIRST FLOOR - FURNITURE PLAN - AREA 'D'	12667716	P-502	DETAILS	12667773	E-301	EMPLOYEE LOUNGE ELEVATIONS	12667834
HM003	SECOND FLOOR HAZARDOUS MATERIALS REMOVAL PLAN	12667658	AI105	FIRST FLOOR - FURNITURE PLAN - AREA 'E'	12667717	P-601	RISER DIAGRAMS	12667774	E-401	ENLARGED ELECTRICAL ROOM PLAN	12667835
STRUCTURAL			AI106	SECOND FLOOR - FURNITURE PLAN - AREA 'A'	12667718	P-602	RISER DIAGRAMS	12667775	E-501	LIGHTING DETAILS	12667836
S-001	GENERAL NOTES	12667659	AI107	SECOND FLOOR - FURNITURE PLAN - AREA 'B'	12667719	MECHANICAL					
S-002	TYPICAL DETAILS	12667660	AI108	SECOND FLOOR - FURNITURE PLAN - AREA 'C'	12667720	M-001	LEGEND ABBREVIATIONS & SCHEDULES	12667776	E-502	LIGHTING DETAILS	12667837
S-101	OVERALL FIRST FLOOR PLAN	12667661	AI109	SECOND FLOOR - FURNITURE PLAN - AREA 'D'	12667721	M-001	LEGEND ABBREVIATIONS & SCHEDULES	12667776	E-503	LIGHTING FIXTURE SCHEDULE AND DETAILS	12667838
S-102	OVERALL SECOND FLOOR PLAN	12667662	AI401	SECOND FLOOR - FURNITURE PLAN - ENLARGED PLANS	12667722	MD101	FIRST FLOOR - DEMOLITION PLAN - AREA 'A'	12667777	E-601	ONE LINE DIAGRAM	12667839
ARCHITECTURAL			AF101	FIRST FLOOR - FINISH PLAN - AREA 'A'	12667723	MD102	FIRST FLOOR - DEMOLITION PLAN - AREA 'B'	12667778	E-602	PANELBOARD AND SWITCHBOARD SCHEDULES	12667840
A-001	LEGENDS, ABBREVIATIONS, PARTITION TYPES AND NOTES	12667663	AF102	FIRST FLOOR - FINISH PLAN - AREA 'B'	12667724	MD103	FIRST FLOOR - DEMOLITION PLAN - AREA 'C'	12667779	E-603	PANELBOARD SCHEDULES	12667841
A-002	EXISTING FIRST FLOOR PLAN	12667664	AF103	FIRST FLOOR - FINISH PLAN - AREA 'C'	12667725	MD104	FIRST FLOOR - DEMOLITION PLAN - AREA 'D'	12667780	E-604	PANELBOARD AND LIGHTING FIXTURE SCHEDULES	12667842
A-003	EXISTING SECOND FLOOR PLAN	12667665	AF104	FIRST FLOOR - FINISH PLAN - AREA 'D'	12667726	MD105	FIRST FLOOR - DEMOLITION PLAN - AREA 'E'	12667781	E-605	PANELBOARD SCHEDULES	12667843
A-004	FIRST FLOOR COMPOSITE PLAN	12667666	AF105	FIRST FLOOR - FINISH PLAN - AREA 'E'	12667727	MD106	SECOND FLOOR - DEMOLITION PLAN - AREA 'A'	12667782	E-606	PANELBOARD SCHEDULES	12667844
A-005	SECOND FLOOR COMPOSITE PLAN	12667667	AF106	SECOND FLOOR - FINISH PLAN - AREA 'A'	12667728	MD107	SECOND FLOOR - DEMOLITION PLAN - AREA 'B'	12667783	E-607	LIGHT CONTROL DIAGRAMS	12667845
AD101	FIRST FLOOR - DEMOLITION PLAN - AREA 'A'	12667668	AF107	SECOND FLOOR - FINISH PLAN - AREA 'B'	12667729	MD108	SECOND FLOOR - DEMOLITION PLAN - AREA 'C'	12667784	E-608	LIGHT CONTROL DIAGRAMS	12667846
AD102	FIRST FLOOR - DEMOLITION PLAN - AREA 'B'	12667669	AF108	SECOND FLOOR - FINISH PLAN - AREA 'C'	12667730	MD109	SECOND FLOOR - DEMOLITION PLAN - AREA 'D'	12667785	E-609	LIGHT CONTROL DIAGRAMS	12667847
AD103	FIRST FLOOR - DEMOLITION PLAN - AREA 'C'	12667670	AF109	SECOND FLOOR - FINISH PLAN - AREA 'D'	12667731	MD110	MECHANICAL ROOF DEMOLITION PLAN	12667786	E-801	PHOTOS	12667848
AD104	FIRST FLOOR - DEMOLITION PLAN - AREA 'D'	12667671	A-801	PHOTOS - EXISTING COMMISSARY	12667732	M-101	FIRST FLOOR - DUCTWORK PLAN - AREA 'A'	12667787	ED901	BID OPTION 1 - SECOND FLOOR DEMOLITION PLAN - AREA 'A'	12667849
AD105	FIRST FLOOR - DEMOLITION PLAN - AREA 'E'	12667672	A-802	PHOTOS - EXISTING COMMISSARY	12667733	M-102	FIRST FLOOR - DUCTWORK PLAN - AREA 'B'	12667788	ED902	BID OPTION 1 - SECOND FLOOR DEMOLITION PLAN - AREA 'B'	12667850
AD106	SECOND FLOOR - DEMOLITION PLAN - AREA 'A'	12667673	A-901	BID OPTION 3 - ESCALATOR REPLACEMENT PLANS	12667734	M-103	FIRST FLOOR - DUCTWORK PLAN - AREA 'C'	12667789	ED903	BID OPTION 1 - SECOND FLOOR DEMOLITION PLAN - AREA 'C'	12667851
AD107	SECOND FLOOR - DEMOLITION PLAN - AREA 'B'	12667674	A-902	BID OPTION 3 - ESCALATOR REPLACEMENT ELEVATION & SECTION	12667735	M-104	FIRST FLOOR - DUCTWORK PLAN - AREA 'D'	12667790	ED904	BID OPTION 1 - SECOND FLOOR DEMOLITION PLAN - AREA 'D'	12667852
AD108	SECOND FLOOR - DEMOLITION PLAN - AREA 'C'	12667675	A-903	BID OPTION 4 - BUILDING SIGNAGE	12667736	M-105	FIRST FLOOR - DUCTWORK PLAN - AREA 'E'	12667791	ED905	BID OPTION 2 - FIRST FLOOR DEMOLITION PLAN - AREA 'A'	12667853
AD109	SECOND FLOOR - DEMOLITION PLAN - AREA 'D'	12667676	A-904	BID OPTION 5 - ADMINISTRATIVE AREA FINISHES	12667737	M-106	SECOND FLOOR - DUCTWORK PLAN - AREA 'A'	12667792	ED906	BID OPTION 2 - FIRST FLOOR DEMOLITION PLAN - AREA 'C'	12667854
AD110	FIRST FLOOR - DEMOLITION CEILING PLAN	12667677	A-905	BID OPTION #6 - MONUMENT SIGN	12667738	M-107	SECOND FLOOR - DUCTWORK PLAN - AREA 'B'	12667793	ED907	BID OPTION 2 - FIRST FLOOR DEMOLITION PLAN - AREA 'E'	12667855
AD111	SECOND FLOOR - DEMOLITION CEILING PLAN	12667678	FOOD SERVICE			M-108	SECOND FLOOR - DUCTWORK PLAN - AREA 'C'	12667794	E-901	BID OPTION 1 - SECOND FLOOR LIGHTING PLAN - AREA 'A'	12667856
A-101	FIRST FLOOR - WORK PLAN - AREA 'A'	12667679	QF001	BEER CAVE, REACH-IN COOLERS, AND WALK-IN COOLER & FREEZER	12667739	M-109	SECOND FLOOR - DUCTWORK PLAN - AREA 'D'	12667795	E-902	BID OPTION 1 - SECOND FLOOR LIGHTING PLAN - AREA 'B'	12667857
A-102	FIRST FLOOR - WORK PLAN - AREA 'B'	12667680	QF002	FOODSERVICE EQUIPMENT PLUMBING ROUGH-IN PLAN	12667740	M-110	MECHANICAL ROOF PLAN	12667796	E-903	BID OPTION 1 - SECOND FLOOR LIGHTING PLAN - AREA 'C'	12667858
A-103	FIRST FLOOR - WORK PLAN - AREA 'C'	12667681	QF003	FOODSERVICE EQUIPMENT ELECTRICAL ROUGH-IN PLAN	12667741	M-501	DETAILS	12667797	E-904	BID OPTION 1 - SECOND FLOOR LIGHTING PLAN - AREA 'D'	12667859
A-104	FIRST FLOOR - WORK PLAN - AREA 'D'	12667682	FIRE PROTECTION			M-502	DETAILS	12667798	E-905	BID OPTION 2 - FIRST FLOOR LIGHTING PLAN - AREA 'A'	12667860
A-105	FIRST FLOOR - WORK PLAN - AREA 'E'	12667683	F-001	GENERAL NOTES, LEGEND AND MATRIX	12667742	M-601	SCHEDULES	12667799	E-906	BID OPTION 2 - FIRST FLOOR LIGHTING PLAN - AREA 'A'	12667861
A-106	SECOND FLOOR - WORK PLAN - AREA 'A'	12667684	F-101	FIRST FLOOR FIRE PROTECTION PLAN - AREA 'A'	12667743	M-602	SCHEDULES	12667800	E-907	BID OPTION 2 - FIRST FLOOR LIGHTING PLAN - AREA 'E'	12667862
A-107	SECOND FLOOR - WORK PLAN - AREA 'B'	12667685	F-102	FIRST FLOOR FIRE PROTECTION PLAN - AREA 'B'	12667744	M-701	CONTROLS AND SEQUENCE OF OPERATIONS	12667801	E-908	BID OPTION 3 - FIRST FLOOR POWER PLAN - AREA 'A'	12667863
A-108	SECOND FLOOR - WORK PLAN - AREA 'C'	12667686	F-103	FIRST FLOOR FIRE PROTECTION PLAN - AREA 'C'	12667745	ELECTRICAL					
A-109	SECOND FLOOR - WORK PLAN - AREA 'D'	12667687	F-104	FIRST FLOOR FIRE PROTECTION PLAN - AREA 'D'	12667746	E-001	LEGEND AND ABBREVIATIONS	12667802	E-909	BID OPTION 4 - BUILDING SIGNAGE	12667864
A-110	FIRST FLOOR - COMPOSITE CEILING PLAN	12667688	F-105	FIRST FLOOR FIRE PROTECTION PLAN - AREA 'E'	12667747	E-002	GENERAL NOTES	12667803	T-001	LEGEND, NOTES & ABBREVIATIONS	12667865
A-111	FIRST FLOOR - CEILING PLAN - AREA 'A'	12667689	F-106	SECOND FLOOR FIRE PROTECTION PLAN - AREA 'A'	12667748	ED101	FIRST FLOOR - DEMOLITION PLAN - AREA 'A'	12667804	T-101	FIRST FLOOR - TELECOMMUNICATIONS PLAN - AREA 'A'	12667866
A-112	FIRST FLOOR - CEILING PLAN - AREA 'B'	12667690	F-107	SECOND FLOOR FIRE PROTECTION PLAN - AREA 'B'	12667749	ED102	FIRST FLOOR - DEMOLITION PLAN - AREA 'B'	12667805	T-102	FIRST FLOOR - TELECOMMUNICATIONS PLAN - AREA 'B'	12667867
A-113	FIRST FLOOR - CEILING PLAN - AREA 'C'	12667691	F-108	SECOND FLOOR FIRE PROTECTION PLAN - AREA 'C'	12667750	ED103	FIRST FLOOR - DEMOLITION PLAN - AREA 'C'	12667806	T-103	FIRST FLOOR - TELECOMMUNICATIONS PLAN - AREA 'C'	12667868
A-114	FIRST FLOOR - CEILING PLAN - AREA 'D'	12667692	F-109	SECOND FLOOR FIRE PROTECTION PLAN - AREA 'D'	12667751	ED104	FIRST FLOOR - DEMOLITION PLAN - AREA 'D'	12667807	T-104	FIRST FLOOR - TELECOMMUNICATIONS PLAN - AREA 'D'	12667869
A-115	FIRST FLOOR - CEILING PLAN - AREA 'E'	12667693	F-201	DETAILS	12667752	ED105	FIRST FLOOR - DEMOLITION PLAN - AREA 'E'	12667808	T-105	FIRST FLOOR - TELECOMMUNICATIONS PLAN - AREA 'E'	12667870
A-116	SECOND FLOOR - COMPOSITE CEILING PLAN	12667694	PLUMBING			ED106	SECOND FLOOR - DEMOLITION PLAN - AREA 'A'	12667809	T-106	SECOND FLOOR - TELECOMMUNICATIONS PLAN - AREA 'A'	12667871
A-117	SECOND FLOOR - CEILING PLAN - AREA 'A'	12667695	P-001	LEGEND ABBREVIATIONS SCHEDULE	12667753	ED107	SECOND FLOOR - DEMOLITION PLAN - AREA 'B'	12667810	T-107	SECOND FLOOR - TELECOMMUNICATIONS PLAN - AREA 'B'	12667872
A-118	SECOND FLOOR - CEILING PLAN - AREA 'B'	12667696	PD101	FIRST FLOOR - DEMOLITION PLAN - AREA 'A'	12667754	ED108	SECOND FLOOR - DEMOLITION PLAN - AREA 'C'	12667811	T-108	SECOND FLOOR - TELECOMMUNICATIONS PLAN - AREA 'C'	12667873
A-119	SECOND FLOOR - CEILING PLAN - AREA 'C'	12667697	PD102	FIRST FLOOR - DEMOLITION PLAN - AREA 'B'	12667755	ED109	SECOND FLOOR - DEMOLITION PLAN - AREA 'D'	12667812	T-109	SECOND FLOOR - TELECOMMUNICATIONS PLAN - AREA 'D'	12667874
A-120	SECOND FLOOR - CEILING PLAN - AREA 'D'	12667698	PD103	FIRST FLOOR - DEMOLITION PLAN - AREA 'C'	12667756	ED401	ENLARGED DEMOLITION PLAN	12667813	T-501	DETAILS	12667875
A-201	BUILDING ELEVATIONS - DEMOLITION AND NEW WORK	12667699	PD104	FIRST FLOOR - DEMOLITION PLAN - AREA 'D'	12667757	ED601	EXISTING ONE LINE DIAGRAM - DEMOLITION	12667814	T-601	DIAGRAMS	12667876
A-401	ENLARGED FLOOR PLANS	12667700				E-101	FIRST FLOOR - LIGHTING PLAN - AREA 'A'	12667815	T-602	TELECOMMUNICATION RISER DIAGRAM	12667877

DATE	APPR.
DESCRIPTION	SYN.
	
	
	
APPROVED FOR COMMANDER NAVFAC ACTIVITY: CDR MARC BERNATH NEXCOM - FACILITIES DIVISION SATISFACTORY TO DATE 07JUL2014 DES. JB DRW. JT CHK. DE PM/DM RDS/PJB BRANCH MANAGER CHIEF ENG/ARCH DWG FIRE PROTECTION	
DEPARTMENT OF THE NAVY NAVAL FACILITIES ENGINEERING COMMAND SUBBASE NEW LONDON GROTON, CT BLDG. 484 - NEX MAIN STORE EXPANSION & RENOVATION DRAWING INDEX	
SCALE: GRAPHIC EPROJECT NO. 1305708 CONSTR. CONTR. NO. N40085-14-C-5203 NAVFAC DRAWING NO. 12667646 SHEET 2 OF 236	
G-002	

1

2

3

4


5

D

C


B

A

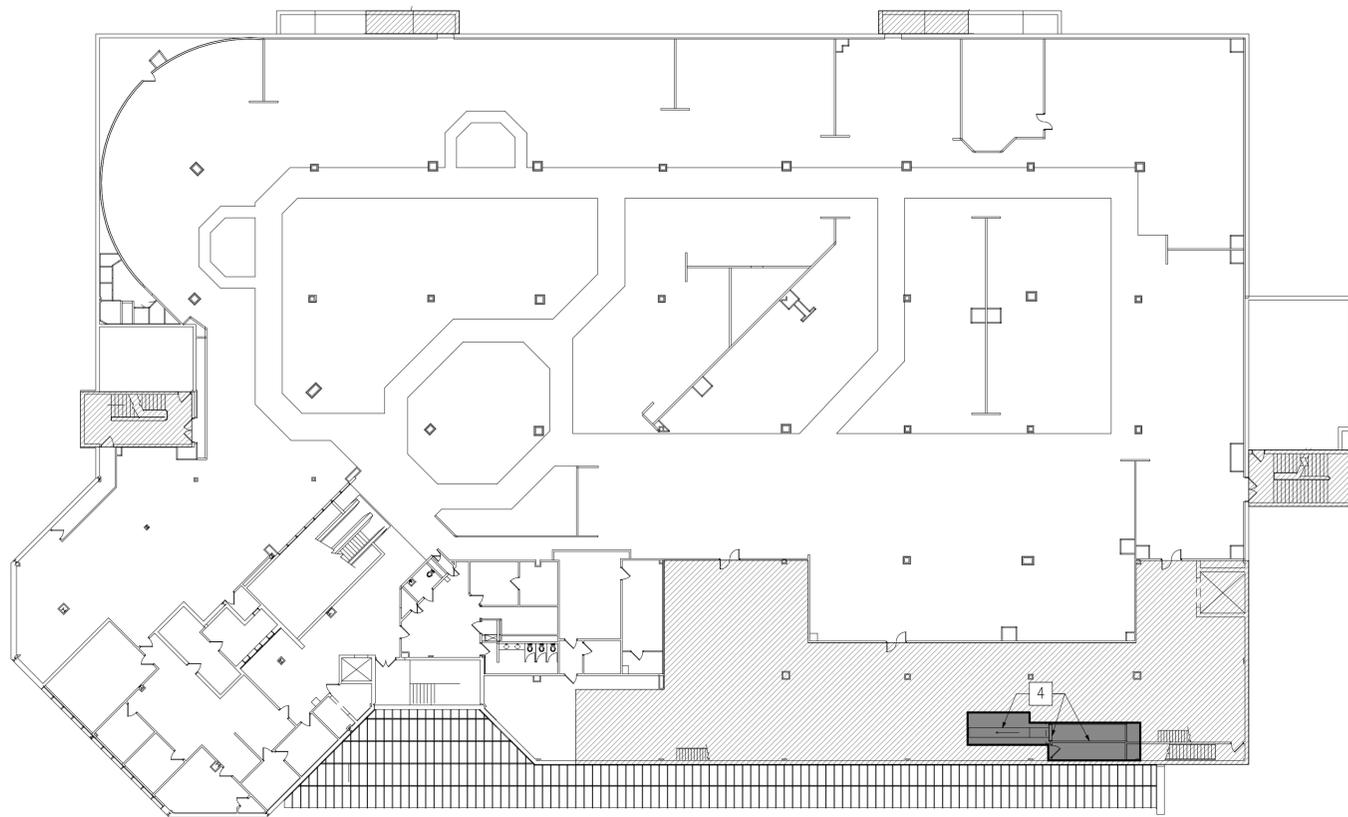

PHASE 1 - SECOND FLOOR

NOT TO SCALE

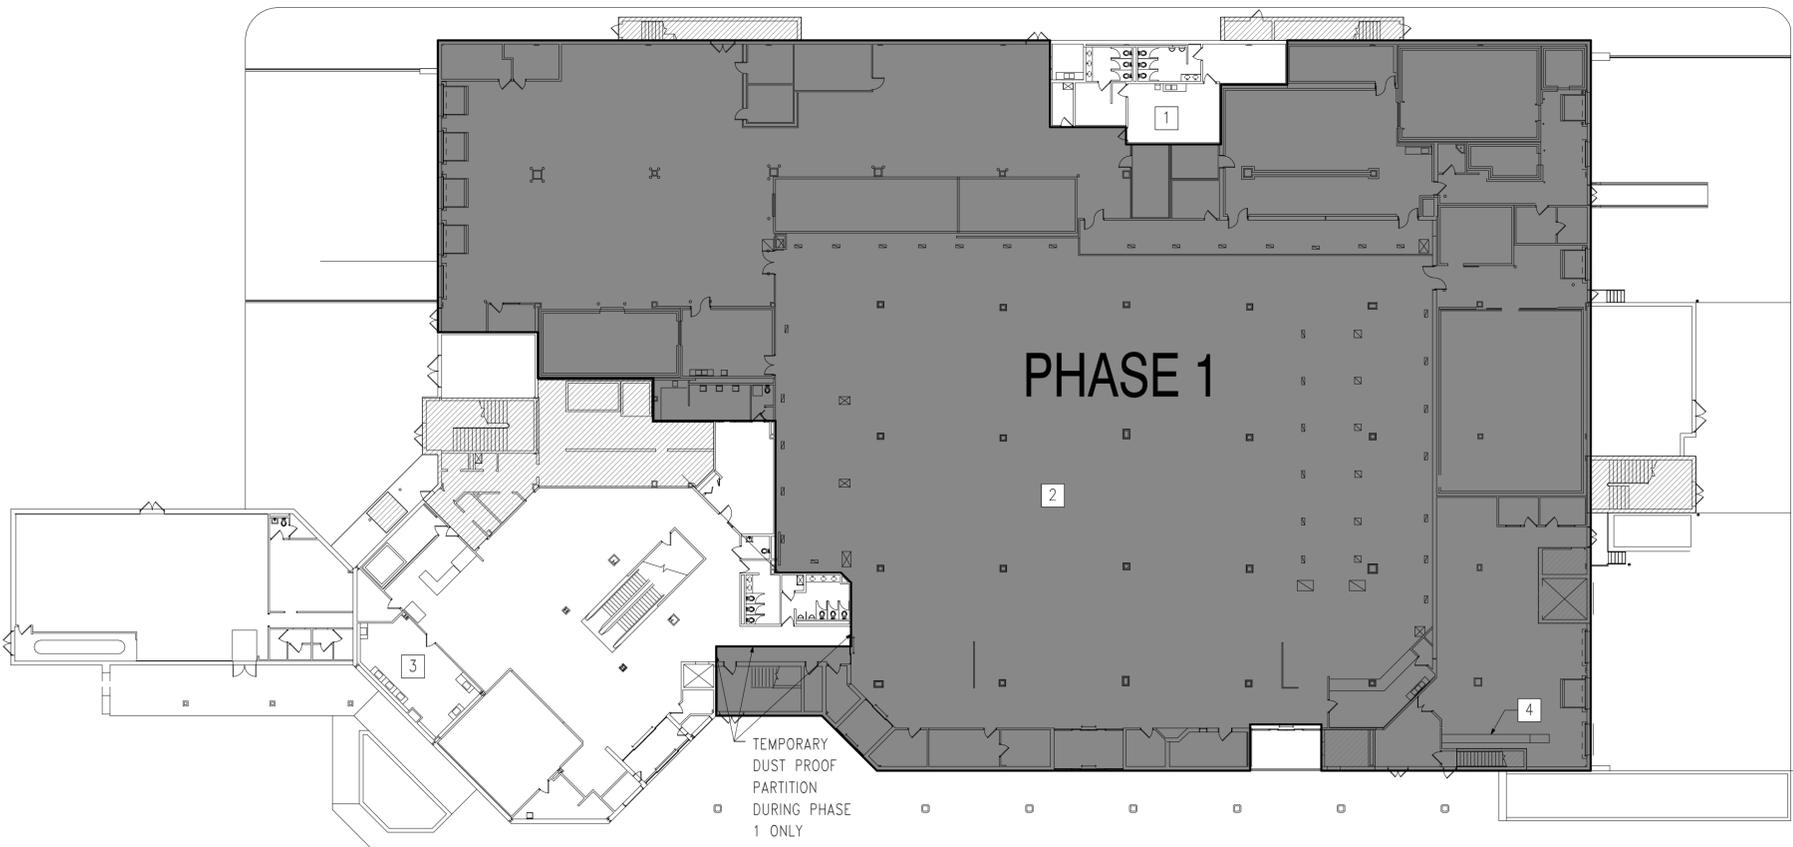

PHASE 1 - FIRST FLOOR

NOT TO SCALE



GENERAL PHASING NOTES

1. NEX WILL OCCUPY SPACES IN THE BUILDING IMMEDIATELY ADJACENT TO AREAS TO BE DEMOLISHED AND RENOVATED, DURING ALL PHASES. PROVIDE TEMPORARY DUSTPROOF BARRIERS BETWEEN PORTIONS OF THE WORK INCLUDED IN EACH PHASE, AND THE ADJACENT AREAS OCCUPIED BY NEX. CONDUCT SELECTIVE DEMOLITION SO NEX'S OPERATIONS WILL NOT BE DISTURBED.
2. PERFORM SELECTIVE DEMOLITION IN A MANNER AND USING EQUIPMENT THAT WILL MINIMIZE NOISE AND VIBRATIONS IN THE EXISTING BUILDING, INCLUDING BUT NOT LIMITED TO PROPER SHORING AND SEPARATION.
3. EXISTING UTILITIES TO PORTIONS OF THE BUILDING OCCUPIED BY NEX MUST REMAIN IN CONTINUOUS UNINTERRUPTED SERVICE DURING THE HOURS OF OPERATION FOR THE NEX. COORDINATE WITH THE GOVERNMENT ANY TEMPORARY DISRUPTIONS IN SERVICE THAT MAY BE REQUIRED. ALL UTILITY OUTAGES EFFECTING THE OCCUPIED PORTION OF THE NEX WILL BE PLANNED AND EXECUTED AFTER NORMAL BUSINESS HOURS.
4. MAINTAIN BUILDING OCCUPANT LIFE SAFETY PER NFPA 101 THROUGHOUT ENTIRE CONSTRUCTION DURATION. PROVIDE CODE COMPLIANT LIFE SAFETY EGRESS PATHWAYS. THESE PATHWAYS SHALL BE KEPT CLEAR AND FREE OF DEBRIS AT ALL TIMES. SAFE CUSTOMER ACCESS MUST BE MAINTAINED AT ALL TIMES.
5. THE BUILDING ENVELOPE WILL NOT BE COMPROMISED DURING ANY PHASE OF CONSTRUCTION. MAINTAIN A CONTINUOUSLY WEATHERTIGHT AND PROPERLY SEALED CONDITION THROUGHOUT ALL PHASES OF CONSTRUCTION.
6. PROVIDE TEMPORARY ENCLOSURE AS REQUIRED TO MAINTAIN EXISTING BUILDING IN A WEATHERTIGHT CONDITION AND TO PROTECT EXISTING FINISHES TO REMAIN. PRIOR TO BEGINNING WORK, PROTECT ALL WALLS, CEILINGS, FLOORS, AND OTHER EXISTING FINISH WORK THAT ARE TO REMAIN. MAINTAIN PROTECTION FOR THE ENTIRE DURATION OF THE WORK, AS NECESSARY TO PROTECT EXISTING WALLS, CEILINGS, FLOORS, AND OTHER EXISTING FINISH WORK.
7. DAMAGE CAUSED BY CONSTRUCTION OPERATIONS SHALL BE REPAIRED BY THE CONTRACTOR TO THE SATISFACTION OF THE CONTRACTING OFFICER AT NO ADDITIONAL COST TO THE GOVERNMENT.
8. EXISTING FURNITURE, FIXTURES, AND EQUIPMENT WILL BE MOVED, REMOVED, OR REPLACED BY NEX PRIOR TO THE START OF EACH PHASE. COORDINATE THE SCHEDULING OF PHASING AND PREPARATION REQUIREMENTS WITH THE CONTRACTING OFFICER.
9. CONTRACTOR SHALL COMPLY WITH ALL APPLICABLE FEDERAL RULES AND REGULATIONS GOVERNING WORKER SECURITY CLEARANCE, FACILITY ACCESS AND WORK IN THE FACILITY (COORDINATE THE DRAWING NOTE(S) WITH THE PROPER SPEC SECTION). THE CONTRACTOR WILL BE ALLOWED ACCESS ONLY TO THE PHASE UNDER CONSTRUCTION; OTHER BUILDING AREAS WILL BE RESTRICTED.
10. THE CONTRACTOR SHALL REVIEW ALL CONTRACT DOCUMENTS FOR FULL SCOPE OF PHASING COORDINATION AND PHASING PLAN REQUIREMENTS. PHASED WORK SHALL PROCEED IN NUMERICAL SEQUENCE.
11. DEVELOP AND SUBMIT A DETAILED CONSTRUCTION PHASING PLAN FOR REVIEW AND APPROVAL PER SPECIFICATION SECTION 01 14 00 WORK RESTRICTIONS. THE PLAN SHALL ENCOMPASS HAZMAT ABATEMENT, DEMOLITION AND NEW WORK. AS PART OF THE PHASING PLAN SUBMITTAL, THE CONTRACTOR SHALL IDENTIFY LIFE SAFETY EGRESS PATHWAYS. IN ADDITION, IDENTIFY NEX, CUSTOMER AND CONTRACTOR ENTRANCES AND EXITS. DEVELOP AND SUBMIT A "WORK AREA SCHEDULE" AS PART OF, OR AS AN APPENDIX, TO THE PHASING PLAN. THE SCHEDULE SHOULD BE BROKEN DOWN BY PHASE AND DETAIL AREAS OF HAZMAT ABATEMENT, DEMOLITION AND NEW WORK.
12. WORK ON THE CURRENT PHASE MUST BE COMPLETED (NEW SYSTEMS TESTED AND OPERATIONAL, SPACES CLEANED READY FOR OCCUPANCY) BEFORE THE CONTRACTOR WILL BE PERMITTED TO BEGIN WORK ON THE NEXT PHASE. THE CURRENT PHASE SHALL BE CERTIFIED HAZMAT-FREE BEFORE THE CONTRACTOR WILL BE ALLOWED TO PERFORM ADDITIONAL WORK ON THAT PHASE.
13. AIR DISTRIBUTION SYSTEMS SERVING THE SEPARATE PHASES MUST BE KEPT SEPARATE AT ALL TIMES TO PREVENT THE MIGRATION OF HAZMAT AND DUST TO UN-RENOVATED SPACES. ENSURE THAT ALL BUILDING ACCESS POINTS FROM MECHANICAL SHAFTS AND WALL PENETRATIONS ARE SECURED, EXCEPT AT SUCH POINTS AS ARE REQUIRED TO PERFORM WORK ON THE CURRENT PHASE OF THE PROJECT.

PHASE 1 KEY NOTES: # THIS SHEET ONLY

1. THE EXISTING EMPLOYEE LOUNGE AND TOILETS ARE TO REMAIN IN OPERATION DURING PHASES 1 & 2. UNTIL THE NEW EMPLOYEE LOUNGE AND TOILETS ON THE SECOND FLOOR ARE OPERATIONAL PROVIDE AND MAINTAIN A TEMPORARY WELL-LIT PROTECTED PATH FROM THE OCCUPIED PORTIONS OF THE BUILDING TO THIS LOCATION AT ALL TIMES.
2. PERFORM SELECTIVE DEMOLITION AND RENOVATIONS IN THE AREA DESIGNATED.
3. NEXCOM TO TEMPORARILY COMBINE BEAUTY AND BARBER SHOP OPERATIONS UNTIL PHASE 4 WORK IS COMPLETED.
4. REMOVE EXISTING CONVEYOR ON FIRST FLOOR, SECOND FLOOR, AND MEZZANINE. REMOVE EXISTING OVERHEAD DOOR AT 2ND FLOOR CONVEYOR OPENING. REMOVE PARTITION BETWEEN STORAGE ROOM 229 AND CONVEYOR ENCLOSURE WALL.

PHASING LEGEND:

- BOUNDARY OF SPECIFIED PHASE
- NOT INCLUDED IN PROJECT SCOPE OF WORK

APPR.	DATE
DESCRIPTION	
JOSEPH D. BOVEE LIC. NO. 008802 ARCHITECT	
ARCHITECTURE INTERIOR DESIGN	
APPROVED:	
FOR COMMANDER NAVFAC:	
ACTIVITY:	
CDR MARC BERNATH NEXCOM - FACILITIES DIVISION	
SATISFACTORY TO DATE: 07JUL2014	
DES. JB	DRW. JT
CHK. DE	
PM/DM	RDS/PJB
BRANCH MANAGER:	
CHIEF ENG/ARCH: DWG	
FIRE PROTECTION:	
DEPARTMENT OF THE NAVY NAVAL FACILITIES ENGINEERING COMMAND NAVAL STATION - NORFOLK, VIRGINIA GROTON, CT SUBBASE NEW LONDON BLDG. 484 - NEX MAIN STORE EXPANSION & RENOVATION PHASING PLAN - PHASE 1	
SCALE:	GRAPHIC
EPROJECT NO.	1305708
CONSTR. CONTR. NO.	N40085-14-C-5203
NAVFAC DRAWING NO.	12667647
SHEET	3 OF 236
G-003	


1 2 3 4 5

D


C

B

A

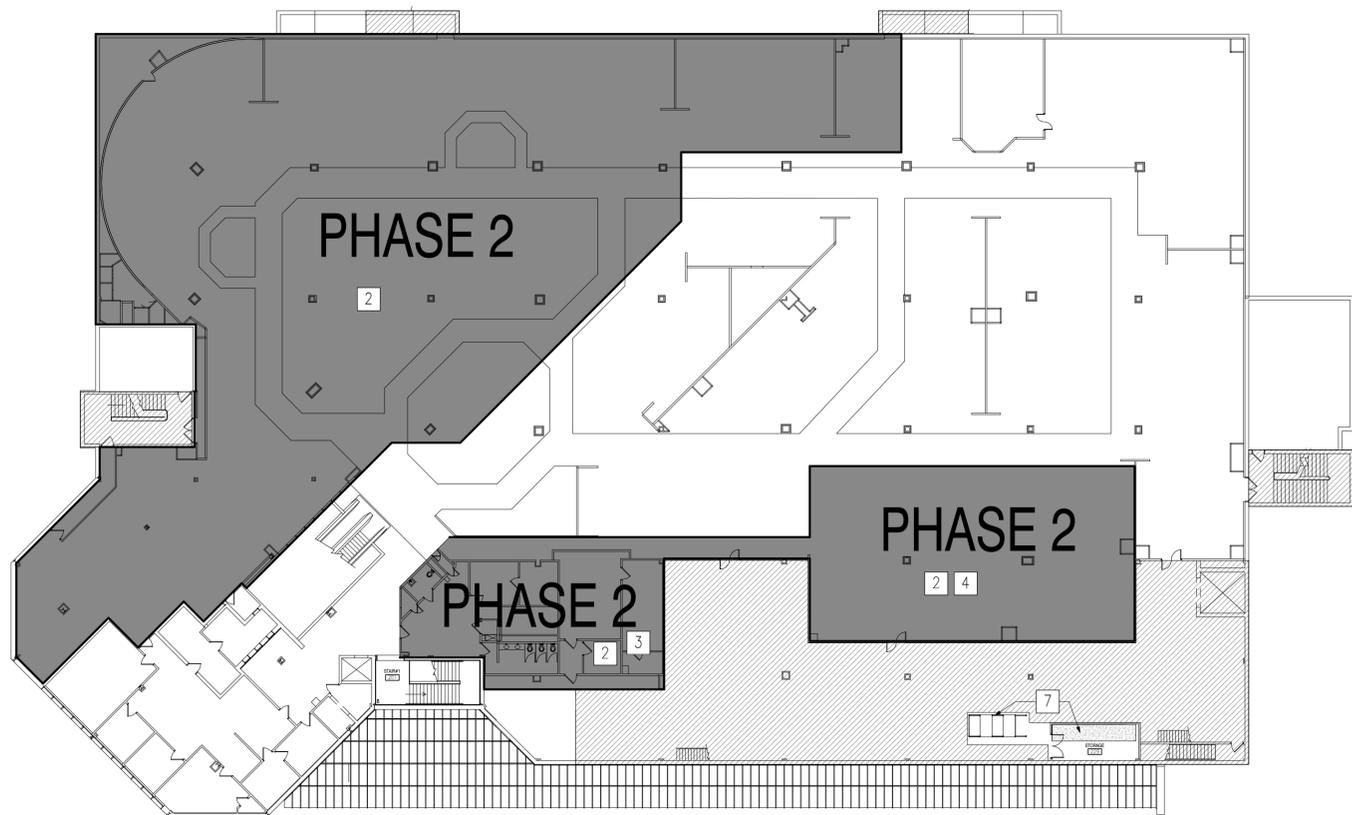

PHASE 2 - SECOND FLOOR
NOT TO SCALE

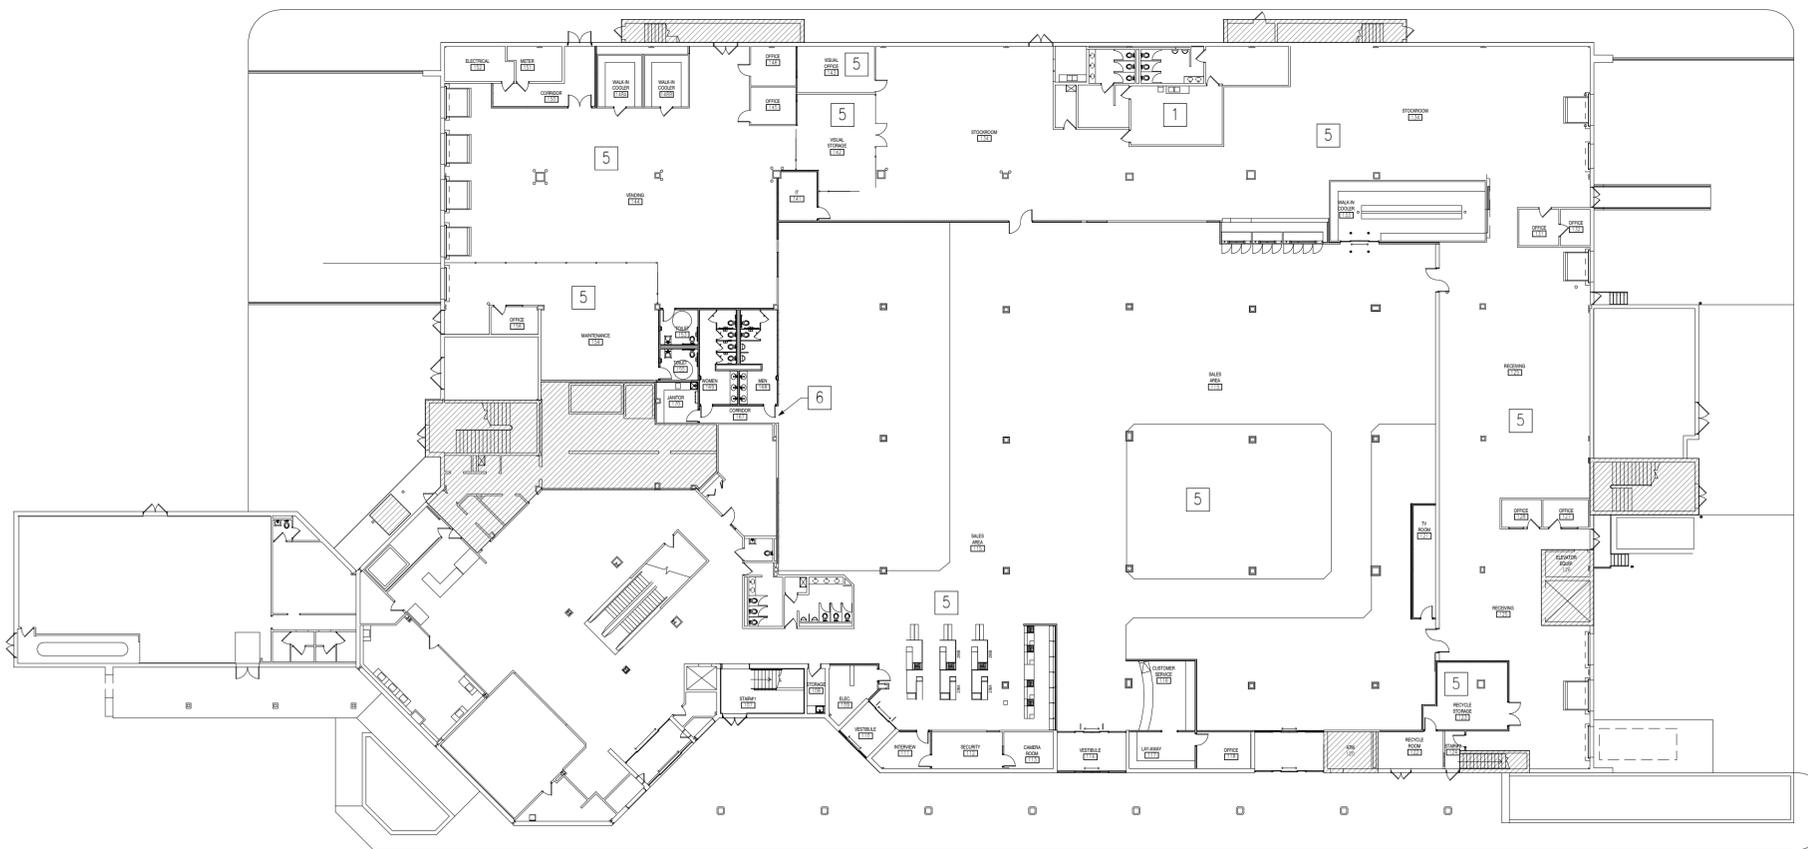

PHASE 2 - FIRST FLOOR
NOT TO SCALE

1 2 3 4 5

GENERAL PHASING NOTES

1. NEX WILL OCCUPY SPACES IN THE BUILDING IMMEDIATELY ADJACENT TO AREAS TO BE DEMOLISHED AND RENOVATED, DURING ALL PHASES. PROVIDE TEMPORARY DUSTPROOF BARRIERS BETWEEN PORTIONS OF THE WORK INCLUDED IN EACH PHASE, AND THE ADJACENT AREAS OCCUPIED BY NEX. CONDUCT SELECTIVE DEMOLITION SO NEX'S OPERATIONS WILL NOT BE DISTURBED.
2. PERFORM SELECTIVE DEMOLITION IN A MANNER AND USING EQUIPMENT THAT WILL MINIMIZE NOISE AND VIBRATIONS IN THE EXISTING BUILDING, INCLUDING BUT NOT LIMITED TO PROPER SHORING AND SEPARATION.
3. EXISTING UTILITIES TO PORTIONS OF THE BUILDING OCCUPIED BY NEX MUST REMAIN IN CONTINUOUS UNINTERRUPTED SERVICE DURING THE HOURS OF OPERATION FOR THE NEX. COORDINATE WITH THE GOVERNMENT ANY TEMPORARY DISRUPTIONS IN SERVICE THAT MAY BE REQUIRED. ALL UTILITY OUTAGES AFFECTING THE OCCUPIED PORTION OF THE NEX WILL BE PLANNED AND EXECUTED AFTER NORMAL BUSINESS HOURS.
4. MAINTAIN BUILDING OCCUPANT LIFE SAFETY PER NFPA 101 THROUGHOUT ENTIRE CONSTRUCTION DURATION. PROVIDE CODE COMPLIANT LIFE SAFETY EGRESS PATHWAYS. THESE PATHWAYS SHALL BE KEPT CLEAR AND FREE OF DEBRIS AT ALL TIMES. SAFE CUSTOMER ACCESS MUST BE MAINTAINED AT ALL TIMES.
5. THE BUILDING ENVELOPE WILL NOT BE COMPROMISED DURING ANY PHASE OF CONSTRUCTION. MAINTAIN A CONTINUOUSLY WEATHERTIGHT AND PROPERLY SEALED CONDITION THROUGHOUT ALL PHASES OF CONSTRUCTION.
6. PROVIDE TEMPORARY ENCLOSURE AS REQUIRED TO MAINTAIN EXISTING BUILDING IN A WEATHERTIGHT CONDITION AND TO PROTECT EXISTING FINISHES TO REMAIN. PRIOR TO BEGINNING WORK, PROTECT ALL WALLS, CEILINGS, FLOORS, AND OTHER EXISTING FINISH WORK THAT ARE TO REMAIN. MAINTAIN PROTECTION FOR THE ENTIRE DURATION OF THE WORK, AS NECESSARY TO PROTECT EXISTING WALLS, CEILINGS, FLOORS, AND OTHER EXISTING FINISH WORK.
7. DAMAGE CAUSED BY CONSTRUCTION OPERATIONS SHALL BE REPAIRED BY THE CONTRACTOR TO THE SATISFACTION OF THE CONTRACTING OFFICER AT NO ADDITIONAL COST TO THE GOVERNMENT.
8. EXISTING FURNITURE, FIXTURES, AND EQUIPMENT WILL BE MOVED, REMOVED, OR REPLACED BY NEX PRIOR TO THE START OF EACH PHASE. COORDINATE THE SCHEDULING OF PHASING AND PREPARATION REQUIREMENTS WITH THE CONTRACTING OFFICER.
9. CONTRACTOR SHALL COMPLY WITH ALL APPLICABLE FEDERAL RULES AND REGULATIONS GOVERNING WORKER SECURITY CLEARANCE, FACILITY ACCESS AND WORK IN THE FACILITY (COORDINATE THE DRAWING NOTE(S) WITH THE PROPER SPEC SECTION). THE CONTRACTOR WILL BE ALLOWED ACCESS ONLY TO THE PHASE UNDER CONSTRUCTION; OTHER BUILDING AREAS WILL BE RESTRICTED.
10. THE CONTRACTOR SHALL REVIEW ALL CONTRACT DOCUMENTS FOR FULL SCOPE OF PHASING COORDINATION AND PHASING PLAN REQUIREMENTS. PHASED WORK SHALL PROCEED IN NUMERICAL SEQUENCE.
11. DEVELOP AND SUBMIT A DETAILED CONSTRUCTION PHASING PLAN FOR REVIEW AND APPROVAL PER SPECIFICATION SECTION 01 14 00 WORK RESTRICTIONS. THE PLAN SHALL ENCOMPASS HAZMAT ABATEMENT, DEMOLITION AND NEW WORK. AS PART OF THE PHASING PLAN SUBMITTAL, THE CONTRACTOR SHALL IDENTIFY LIFE SAFETY EGRESS PATHWAYS. IN ADDITION, IDENTIFY NEX, CUSTOMER AND CONTRACTOR ENTRANCES AND EXITS. DEVELOP AND SUBMIT A "WORK AREA SCHEDULE" AS PART OF, OR AS AN APPENDIX, TO THE PHASING PLAN. THE SCHEDULE SHOULD BE BROKEN DOWN BY PHASE AND DETAIL AREAS OF HAZMAT ABATEMENT, DEMOLITION AND NEW WORK.
12. WORK ON THE CURRENT PHASE MUST BE COMPLETED (NEW SYSTEMS TESTED AND OPERATIONAL, SPACES CLEANED READY FOR OCCUPANCY) BEFORE THE CONTRACTOR WILL BE PERMITTED TO BEGIN WORK ON THE NEXT PHASE. THE CURRENT PHASE SHALL BE CERTIFIED HAZMAT-FREE BEFORE THE CONTRACTOR WILL BE ALLOWED TO PERFORM ADDITIONAL WORK ON THAT PHASE.
13. AIR DISTRIBUTION SYSTEMS SERVING THE SEPARATE PHASES MUST BE KEPT SEPARATE AT ALL TIMES TO PREVENT THE MIGRATION OF HAZMAT AND DUST TO UN-RENOVATED SPACES. ENSURE THAT ALL BUILDING ACCESS POINTS FROM MECHANICAL SHAFTS AND WALL PENETRATIONS ARE SECURED, EXCEPT AT SUCH POINTS AS ARE REQUIRED TO PERFORM WORK ON THE CURRENT PHASE OF THE PROJECT.

PHASE 2 KEY NOTES: # THIS SHEET ONLY


1. THE EXISTING EMPLOYEE LOUNGE AND TOILETS ARE TO REMAIN IN OPERATION DURING PHASES 1 & 2, UNTIL THE NEW EMPLOYEE LOUNGE AND TOILETS ON THE SECOND FLOOR ARE OPERATIONAL PROVIDE AND MAINTAIN A TEMPORARY WELL-LIT PROTECTED PATH FROM THE OCCUPIED PORTIONS OF THE BUILDING TO THIS LOCATION AT ALL TIMES.
2. PERFORM SELECTIVE DEMOLITION AND RENOVATIONS IN THE AREA DESIGNATED.
3. CONSTRUCT NEW EMPLOYEE LOUNGE, LOCKER ROOM AND TOILETS AS INDICATED IN NEW WORK PLANS.
4. CONSTRUCT NEW SHOE STORAGE ROOM. PROVIDE AND INSTALL MOBILE SHOE RACK STORAGE SYSTEM.
5. PORTIONS OF THE BUILDING RENOVATED IN PRIOR PHASES WILL BE OCCUPIED BY THE NEX AS THEY BECOME AVAILABLE.
6. PROVIDE TEMPORARY 5'-0" WIDE X 7'-0" HIGH OPENING IN WALL TO NEW TOILETS, UNTIL PHASE 5 THEN INFILL OPENING WITH METAL STUDS AND GYPSUM BOARD TO MATCH EXISTING ADJACENT CONSTRUCTION.
7. INFILL CONCRETE SLAB OPENING AT SECOND FLOOR AT AREA VACATED BY THE EXISTING CONVEYOR AND PROVIDE NEW WORK INDICATED IN ENLARGED ROOM 229. INFILL MEZZANINE LEVEL FLOOR GRATING AND SUPPORT BEAMS AT OPENING VACATED BY THE EXISTING CONVEYOR.

PHASING LEGEND:




APPR.	DATE
DESCRIPTION	
 COMMONWEALTH OF VIRGINIA JOSEPH D. BOVEE LIC. NO. 008802 ARCHITECT	
 ARCHITECTURE INTERIOR DESIGN	
APPROVED FOR COMMANDER NAVFAC ACTIVITY CDR MARC BERNATH NEXCOM - FACILITIES DIVISION SATISFACTORY TO DATE 07JUL2014 DES. JB DRW. JT CHK. DE PM/DM RDS/PJB BRANCH MANAGER CHIEF ENG/ARCH DWG FIRE PROTECTION	
DEPARTMENT OF THE NAVY NAVAL FACILITIES ENGINEERING COMMAND NAVAL STATION - NORFOLK, VIRGINIA GROTON, CT SUBBASE NEW LONDON BLDG. 484 - NEX MAIN STORE EXPANSION & RENOVATION PHASING PLAN - PHASE 2	
SCALE: GRAPHIC	
EPROJECT NO. 1305708	
CONSTR. CONTR. NO. N40085-14-C-5203	
NAVFAC DRAWING NO. 12667648	
SHEET 4 OF 236	
G-004	

PHASE 3

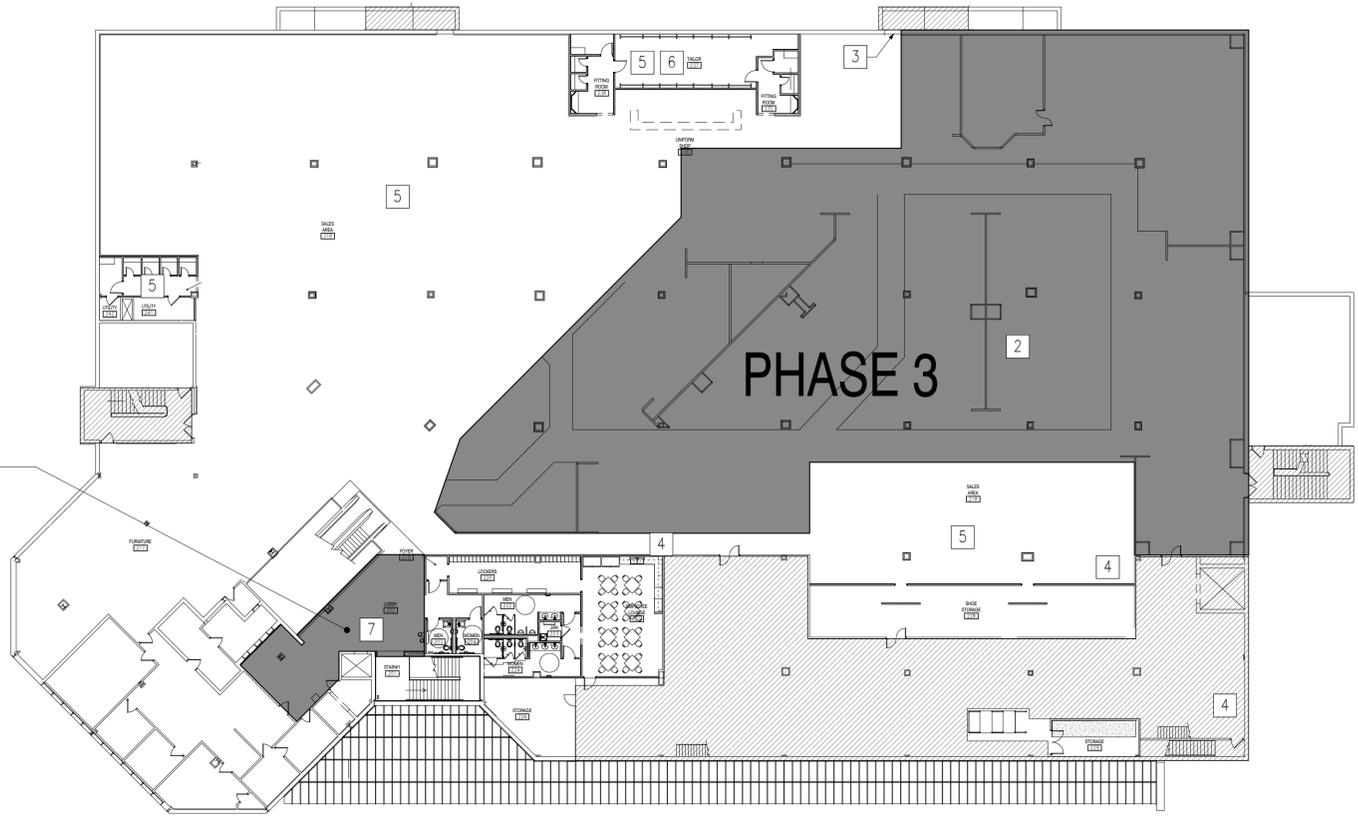

PHASE 3 - SECOND FLOOR
NOT TO SCALE

PHASE 3

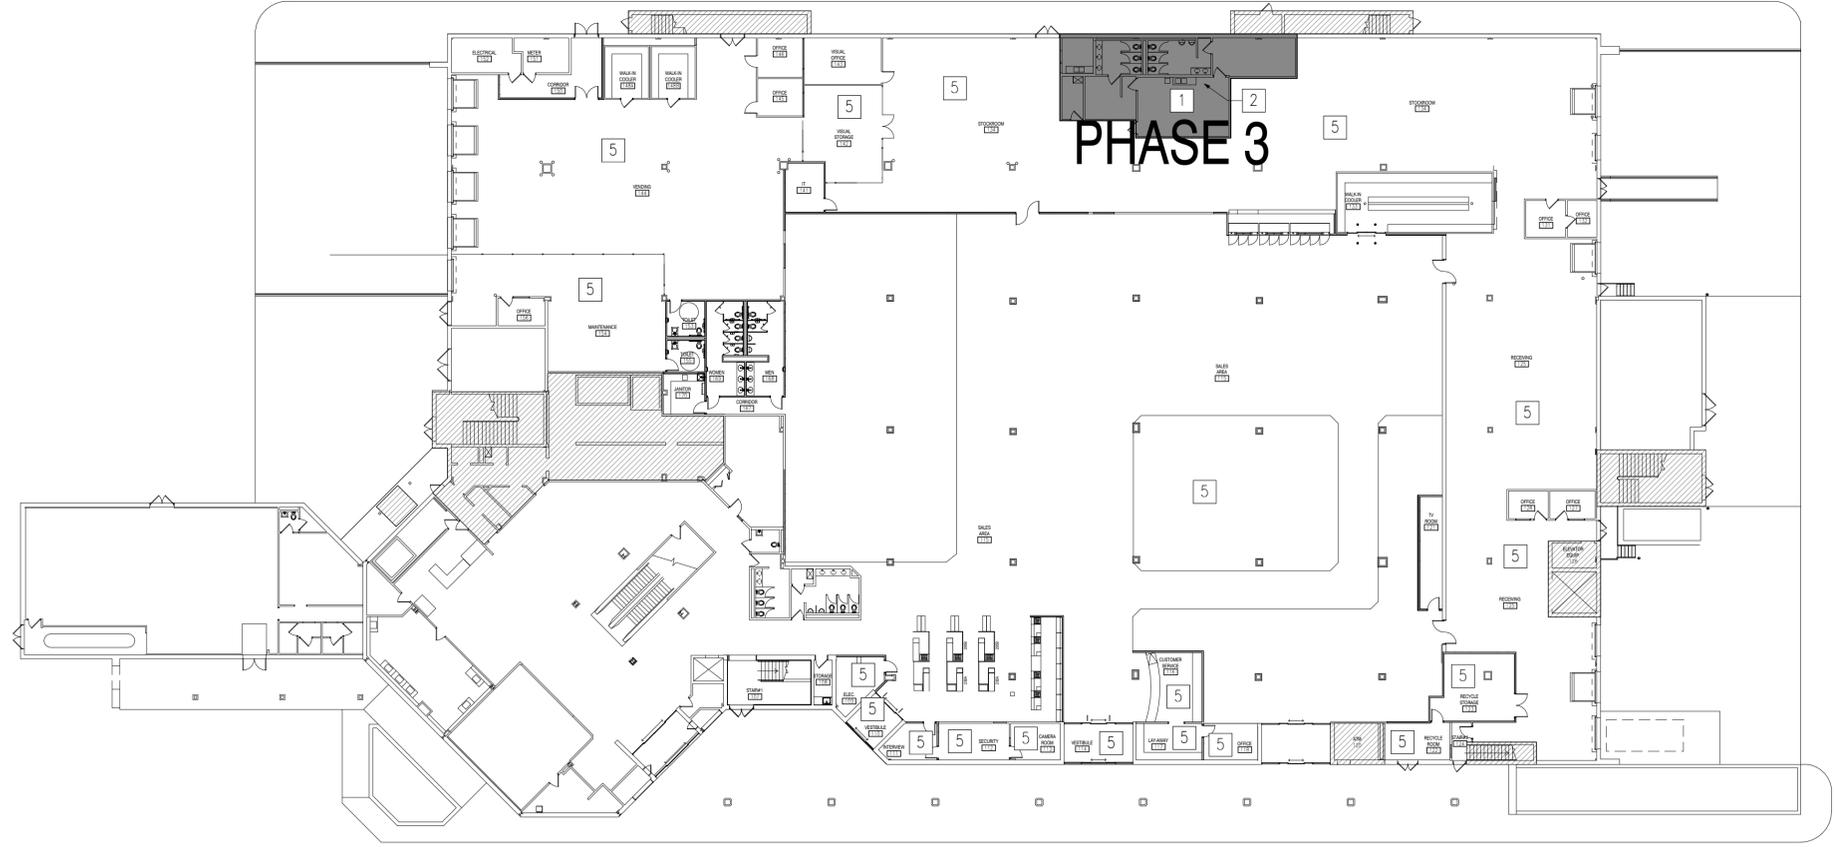

PHASE 3 - FIRST FLOOR
NOT TO SCALE

GENERAL PHASING NOTES

- NEX WILL OCCUPY SPACES IN THE BUILDING IMMEDIATELY ADJACENT TO AREAS TO BE DEMOLISHED AND RENOVATED, DURING ALL PHASES. PROVIDE TEMPORARY DUSTPROOF BARRIERS BETWEEN PORTIONS OF THE WORK INCLUDED IN EACH PHASE, AND THE ADJACENT AREAS OCCUPIED BY NEX. CONDUCT SELECTIVE DEMOLITION SO NEX'S OPERATIONS WILL NOT BE DISTURBED.
- PERFORM SELECTIVE DEMOLITION IN A MANNER AND USING EQUIPMENT THAT WILL MINIMIZE NOISE AND VIBRATIONS IN THE EXISTING BUILDING, INCLUDING BUT NOT LIMITED TO PROPER SHORING AND SEPARATION.
- EXISTING UTILITIES TO PORTIONS OF THE BUILDING OCCUPIED BY NEX MUST REMAIN IN CONTINUOUS UNINTERRUPTED SERVICE DURING THE HOURS OF OPERATION FOR THE NEX. COORDINATE WITH THE GOVERNMENT ANY TEMPORARY DISRUPTIONS IN SERVICE THAT MAY BE REQUIRED. ALL UTILITY OUTAGES EFFECTING THE OCCUPIED PORTION OF THE NEX WILL BE PLANNED AND EXECUTED AFTER NORMAL BUSINESS HOURS.
- MAINTAIN BUILDING OCCUPANT LIFE SAFETY PER NFPA 101 THROUGHOUT ENTIRE CONSTRUCTION DURATION. PROVIDE CODE COMPLIANT LIFE SAFETY EGRESS PATHWAYS. THESE PATHWAYS SHALL BE KEPT CLEAR AND FREE OF DEBRIS AT ALL TIMES. SAFE CUSTOMER ACCESS MUST BE MAINTAINED AT ALL TIMES.
- THE BUILDING ENVELOPE WILL NOT BE COMPROMISED DURING ANY PHASE OF CONSTRUCTION. MAINTAIN A CONTINUOUSLY WEATHERTIGHT AND PROPERLY SEALED CONDITION THROUGHOUT ALL PHASES OF CONSTRUCTION.
- PROVIDE TEMPORARY ENCLOSURE AS REQUIRED TO MAINTAIN EXISTING BUILDING IN A WEATHERTIGHT CONDITION AND TO PROTECT EXISTING FINISHES TO REMAIN. PRIOR TO BEGINNING WORK, PROTECT ALL WALLS, CEILINGS, FLOORS, AND OTHER EXISTING FINISH WORK THAT ARE TO REMAIN. MAINTAIN PROTECTION FOR THE ENTIRE DURATION OF THE WORK, AS NECESSARY TO PROTECT EXISTING WALLS, CEILINGS, FLOORS, AND OTHER EXISTING FINISH WORK.
- DAMAGE CAUSED BY CONSTRUCTION OPERATIONS SHALL BE REPAIRED BY THE CONTRACTOR TO THE SATISFACTION OF THE CONTRACTING OFFICER AT NO ADDITIONAL COST TO THE GOVERNMENT.
- EXISTING FURNITURE, FIXTURES, AND EQUIPMENT WILL BE MOVED, REMOVED, OR REPLACED BY NEX PRIOR TO THE START OF EACH PHASE. COORDINATE THE SCHEDULING OF PHASING AND PREPARATION REQUIREMENTS WITH THE CONTRACTING OFFICER.
- CONTRACTOR SHALL COMPLY WITH ALL APPLICABLE FEDERAL RULES AND REGULATIONS GOVERNING WORKER SECURITY CLEARANCE, FACILITY ACCESS AND WORK IN THE FACILITY (COORDINATE THE DRAWING NOTE(S) WITH THE PROPER SPEC SECTION). THE CONTRACTOR WILL BE ALLOWED ACCESS ONLY TO THE PHASE UNDER CONSTRUCTION; OTHER BUILDING AREAS WILL BE RESTRICTED.
- THE CONTRACTOR SHALL REVIEW ALL CONTRACT DOCUMENTS FOR FULL SCOPE OF PHASING COORDINATION AND PHASING PLAN REQUIREMENTS. PHASED WORK SHALL PROCEED IN NUMERICAL SEQUENCE.
- DEVELOP AND SUBMIT A DETAILED CONSTRUCTION PHASING PLAN FOR REVIEW AND APPROVAL PER SPECIFICATION SECTION 01 14 00 WORK RESTRICTIONS. THE PLAN SHALL ENCOMPASS HAZMAT ABATEMENT, DEMOLITION AND NEW WORK. AS PART OF THE PHASING PLAN SUBMITTAL, THE CONTRACTOR SHALL IDENTIFY LIFE SAFETY EGRESS PATHWAYS. IN ADDITION, IDENTIFY NEX, CUSTOMER AND CONTRACTOR ENTRANCES AND EXITS. DEVELOP AND SUBMIT A "WORK AREA SCHEDULE" AS PART OF, OR AS AN APPENDIX, TO THE PHASING PLAN. THE SCHEDULE SHOULD BE BROKEN DOWN BY PHASE AND DETAIL AREAS OF HAZMAT ABATEMENT, DEMOLITION AND NEW WORK.
- WORK ON THE CURRENT PHASE MUST BE COMPLETED (NEW SYSTEMS TESTED AND OPERATIONAL, SPACES CLEANED READY FOR OCCUPANCY) BEFORE THE CONTRACTOR WILL BE PERMITTED TO BEGIN WORK ON THE NEXT PHASE. THE CURRENT PHASE SHALL BE CERTIFIED HAZMAT-FREE BEFORE THE CONTRACTOR WILL BE ALLOWED TO PERFORM ADDITIONAL WORK ON THAT PHASE.
- AIR DISTRIBUTION SYSTEMS SERVING THE SEPARATE PHASES MUST BE KEPT SEPARATE AT ALL TIMES TO PREVENT THE MIGRATION OF HAZMAT AND DUST TO UN-RENOVATED SPACES. ENSURE THAT ALL BUILDING ACCESS POINTS FROM MECHANICAL SHAFTS AND WALL PENETRATIONS ARE SECURED, EXCEPT AT SUCH POINTS AS ARE REQUIRED TO PERFORM WORK ON THE CURRENT PHASE OF THE PROJECT.

PHASE 3 KEY NOTES:

THIS SHEET ONLY

- WHEN CONSTRUCTION OF NEW 2ND FLOOR EMPLOYEE LOUNGE, LOCKERS, AND TOILETS ARE COMPLETE AND OPERATIONAL, BEGIN SELECTIVE DEMOLITION AND RENOVATIONS AT EXISTING 1ST FLOOR EMPLOYEE LOUNGE AND TOILETS IN THE AREA INDICATED.
- PERFORM SELECTIVE DEMOLITION AND RENOVATIONS IN THE AREA DESIGNATED.
- MAINTAIN MEANS OF EGRESS TO STAIR #4 THROUGHOUT PHASE 3.
- MAINTAIN A MINIMUM 5'-0" WIDE PASSAGE FOR NEX OCCUPANTS BETWEEN THE NEW SHOE SALES AREA (218) AND THE LOBBY (202). PROVIDE TEMPORARY MEANS OF EGRESS THROUGH THE EXISTING STOCK ROOM TO EXISTING EXIT STAIR #2. THE TEMPORARY MEANS OF EGRESS TO STAIR #2 THROUGH THE STOCK ROOM SHALL BE AVAILABLE AT ALL TIMES THAT THE BUILDING IS OCCUPIED AND SHOULD BE CLEARLY MARKED AS A MEANS OF EGRESS.
- PORTIONS OF THE BUILDING RENOVATED IN PRIOR PHASES WILL BE OCCUPIED BY THE NEX AS THEY BECOME AVAILABLE.
- THE NEX WILL RELOCATE TAILOR AND UNIFORM SHOP TO NEW LOCATION DURING PHASE 3.
- MAINTAIN EGRESS TO STAIR #1 AND ACCESS TO PASSENGER ELEVATOR DURING NORMAL NEX STORE HOURS.

PHASING LEGEND:

-  BOUNDARY OF SPECIFIED PHASE
-  NOT INCLUDED IN PROJECT SCOPE OF WORK

APPR.	DATE
SW	DESCRIPTION
	
	
	
ARCHITECTURE INTERIOR DESIGN	
APPROVED	
FOR COMMANDER NAVFAC	
ACTIVITY	
CDR MARC BERNATH NEXCOM - FACILITIES DIVISION	
SATISFACTORY TO DATE 07JUL2014	
DES. JB	DRW. JT
CHK. DE	
PM/DM	RDS/PJB
BRANCH MANAGER	
CHIEF ENG/ARCH	DWG
FIRE PROTECTION	
DEPARTMENT OF THE NAVY NAVAL FACILITIES ENGINEERING COMMAND NAVAL STATION - NORFOLK, VIRGINIA GROTON, CT SUBBASE NEW LONDON BLDG. 484 - NEX MAIN STORE EXPANSION & RENOVATION PHASING PLAN - PHASE 3	
SCALE:	GRAPHIC
EPROJECT NO.	1305708
CONSTR. CONTR. NO.	N40085-14-C-5203
NAVFAC DRAWING NO.	12667649
SHEET	5 OF 236
G-005	

1

2

3

4


5

D

C


B

A

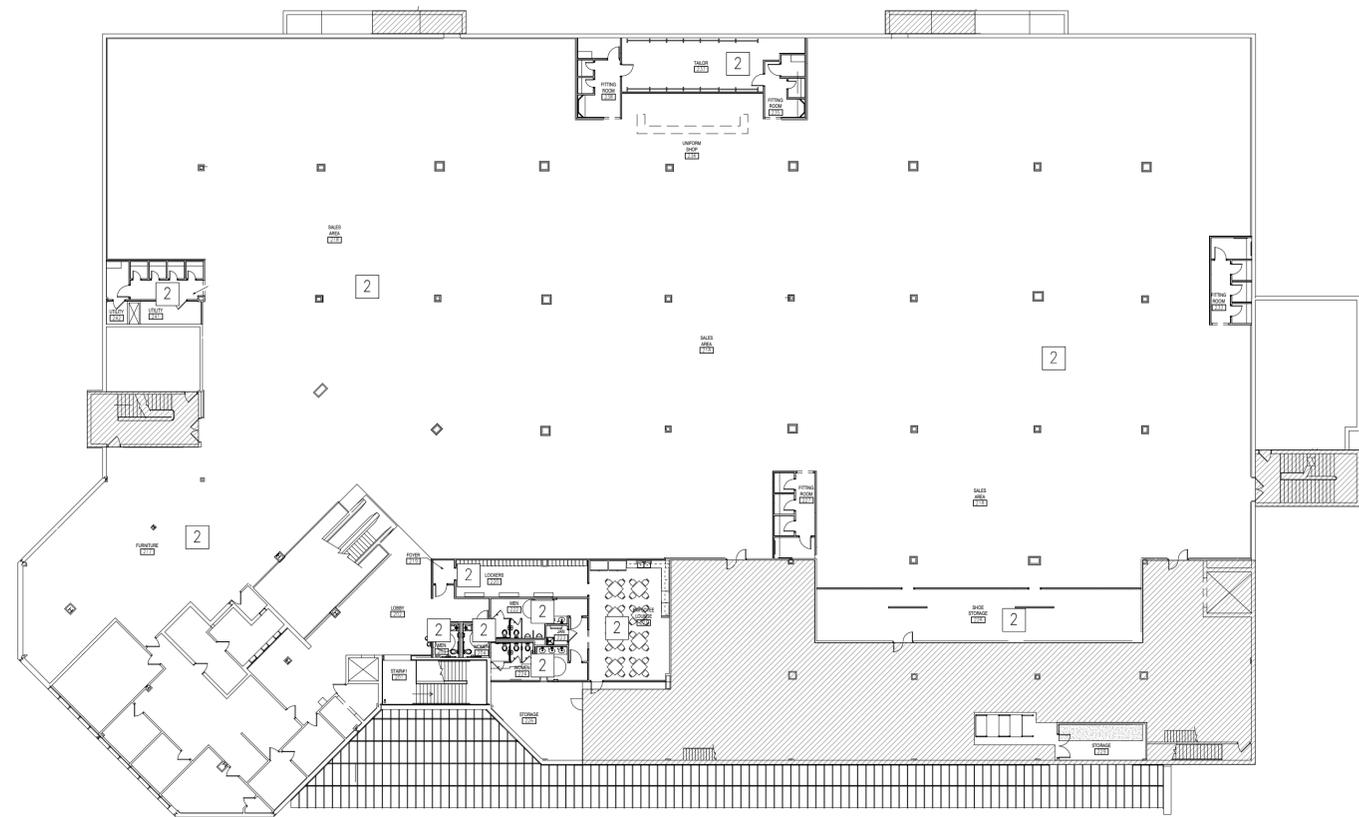

PHASE 4 - SECOND FLOOR

NOT TO SCALE

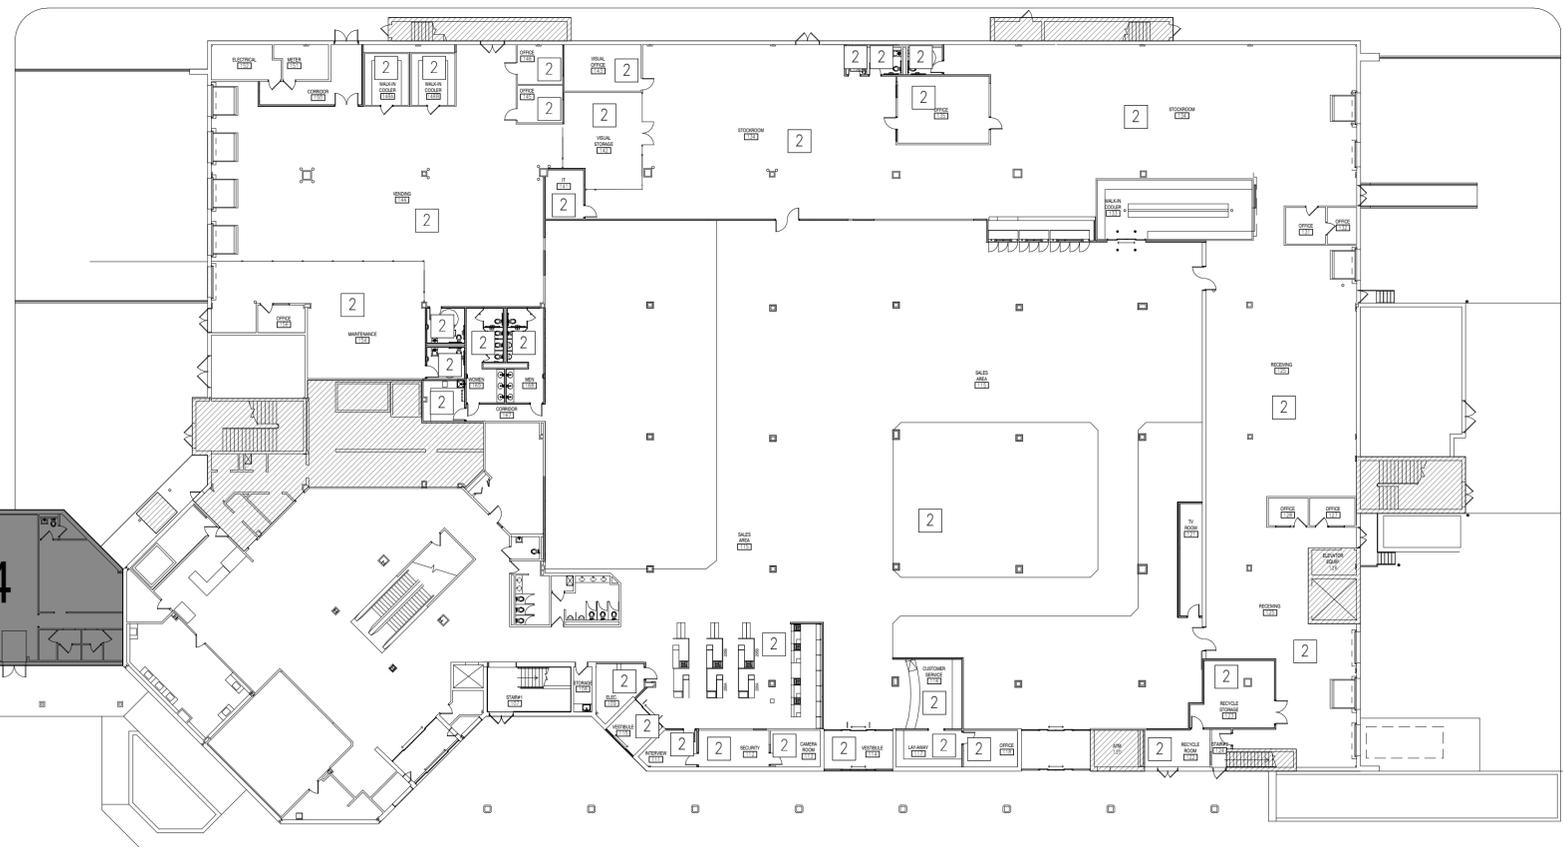

PHASE 4 - FIRST FLOOR

NOT TO SCALE



GENERAL PHASING NOTES

1. NEX WILL OCCUPY SPACES IN THE BUILDING IMMEDIATELY ADJACENT TO AREAS TO BE DEMOLISHED AND RENOVATED, DURING ALL PHASES. PROVIDE TEMPORARY DUSTPROOF BARRIERS BETWEEN PORTIONS OF THE WORK INCLUDED IN EACH PHASE, AND THE ADJACENT AREAS OCCUPIED BY NEX. CONDUCT SELECTIVE DEMOLITION SO NEX'S OPERATIONS WILL NOT BE DISTURBED.
2. PERFORM SELECTIVE DEMOLITION IN A MANNER AND USING EQUIPMENT THAT WILL MINIMIZE NOISE AND VIBRATIONS IN THE EXISTING BUILDING, INCLUDING BUT NOT LIMITED TO PROPER SHORING AND SEPARATION.
3. EXISTING UTILITIES TO PORTIONS OF THE BUILDING OCCUPIED BY NEX MUST REMAIN IN CONTINUOUS UNINTERRUPTED SERVICE DURING THE HOURS OF OPERATION FOR THE NEX. COORDINATE WITH THE GOVERNMENT ANY TEMPORARY DISRUPTIONS IN SERVICE THAT MAY BE REQUIRED. ALL UTILITY OUTAGES EFFECTING THE OCCUPIED PORTION OF THE NEX WILL BE PLANNED AND EXECUTED AFTER NORMAL BUSINESS HOURS.
4. MAINTAIN BUILDING OCCUPANT LIFE SAFETY PER NFPA 101 THROUGHOUT ENTIRE CONSTRUCTION DURATION. PROVIDE CODE COMPLIANT LIFE SAFETY EGRESS PATHWAYS. THESE PATHWAYS SHALL BE KEPT CLEAR AND FREE OF DEBRIS AT ALL TIMES. SAFE CUSTOMER ACCESS MUST BE MAINTAINED AT ALL TIMES.
5. THE BUILDING ENVELOPE WILL NOT BE COMPROMISED DURING ANY PHASE OF CONSTRUCTION. MAINTAIN A CONTINUOUSLY WEATHERTIGHT AND PROPERLY SEALED CONDITION THROUGHOUT ALL PHASES OF CONSTRUCTION.
6. PROVIDE TEMPORARY ENCLOSURE AS REQUIRED TO MAINTAIN EXISTING BUILDING IN A WEATHERTIGHT CONDITION AND TO PROTECT EXISTING FINISHES TO REMAIN. PRIOR TO BEGINNING WORK, PROTECT ALL WALLS, CEILINGS, FLOORS, AND OTHER EXISTING FINISH WORK THAT ARE TO REMAIN. MAINTAIN PROTECTION FOR THE ENTIRE DURATION OF THE WORK, AS NECESSARY TO PROTECT EXISTING WALLS, CEILINGS, FLOORS, AND OTHER EXISTING FINISH WORK.
7. DAMAGE CAUSED BY CONSTRUCTION OPERATIONS SHALL BE REPAIRED BY THE CONTRACTOR TO THE SATISFACTION OF THE CONTRACTING OFFICER AT NO ADDITIONAL COST TO THE GOVERNMENT.
8. EXISTING FURNITURE, FIXTURES, AND EQUIPMENT WILL BE MOVED, REMOVED, OR REPLACED BY NEX PRIOR TO THE START OF EACH PHASE. COORDINATE THE SCHEDULING OF PHASING AND PREPARATION REQUIREMENTS WITH THE CONTRACTING OFFICER.
9. CONTRACTOR SHALL COMPLY WITH ALL APPLICABLE FEDERAL RULES AND REGULATIONS GOVERNING WORKER SECURITY CLEARANCE, FACILITY ACCESS AND WORK IN THE FACILITY (COORDINATE THE DRAWING NOTE(S) WITH THE PROPER SPEC SECTION). THE CONTRACTOR WILL BE ALLOWED ACCESS ONLY TO THE PHASE UNDER CONSTRUCTION; OTHER BUILDING AREAS WILL BE RESTRICTED.
10. THE CONTRACTOR SHALL REVIEW ALL CONTRACT DOCUMENTS FOR FULL SCOPE OF PHASING COORDINATION AND PHASING PLAN REQUIREMENTS. PHASED WORK SHALL PROCEED IN NUMERICAL SEQUENCE.
11. DEVELOP AND SUBMIT A DETAILED CONSTRUCTION PHASING PLAN FOR REVIEW AND APPROVAL PER SPECIFICATION SECTION 01 14 00 WORK RESTRICTIONS. THE PLAN SHALL ENCOMPASS HAZMAT ABATEMENT, DEMOLITION AND NEW WORK. AS PART OF THE PHASING PLAN SUBMITTAL, THE CONTRACTOR SHALL IDENTIFY LIFE SAFETY EGRESS PATHWAYS. IN ADDITION, IDENTIFY NEX, CUSTOMER AND CONTRACTOR ENTRANCES AND EXITS. DEVELOP AND SUBMIT A "WORK AREA SCHEDULE" AS PART OF, OR AS AN APPENDIX, TO THE PHASING PLAN. THE SCHEDULE SHOULD BE BROKEN DOWN BY PHASE AND DETAIL AREAS OF HAZMAT ABATEMENT, DEMOLITION AND NEW WORK.
12. WORK ON THE CURRENT PHASE MUST BE COMPLETED (NEW SYSTEMS TESTED AND OPERATIONAL, SPACES CLEANED READY FOR OCCUPANCY) BEFORE THE CONTRACTOR WILL BE PERMITTED TO BEGIN WORK ON THE NEXT PHASE. THE CURRENT PHASE SHALL BE CERTIFIED HAZMAT-FREE BEFORE THE CONTRACTOR WILL BE ALLOWED TO PERFORM ADDITIONAL WORK ON THAT PHASE.
13. AIR DISTRIBUTION SYSTEMS SERVING THE SEPARATE PHASES MUST BE KEPT SEPARATE AT ALL TIMES TO PREVENT THE MIGRATION OF HAZMAT AND DUST TO UN-RENOVATED SPACES. ENSURE THAT ALL BUILDING ACCESS POINTS FROM MECHANICAL SHAFTS AND WALL PENETRATIONS ARE SECURED, EXCEPT AT SUCH POINTS AS ARE REQUIRED TO PERFORM WORK ON THE CURRENT PHASE OF THE PROJECT.

PHASE 4 KEY NOTES:

THIS SHEET ONLY

1. PERFORM SELECTIVE DEMOLITION AND RENOVATIONS IN THE AREA DESIGNATED.
2. PORTIONS OF THE BUILDING RENOVATED IN PRIOR PHASES WILL BE OCCUPIED BY THE NEX AS THEY BECOME AVAILABLE.

PHASING LEGEND:

-  BOUNDARY OF SPECIFIED PHASE
-  NOT INCLUDED IN PROJECT SCOPE OF WORK

APPR.	DATE	DESCRIPTION	SWN



APPROVED			
FOR COMMANDER NAVFAC			
ACTIVITY	CDR MARC BERNATH NEXCOM - FACILITIES DIVISION		
SATISFACTORY TO	DATE	07JUL2014	
DES. JB	DRW. JT	CHK. DE	
PM/DM	RDS/PJB		
BRANCH MANAGER			
CHIEF ENGR/ARCH	DWG		
FIRE PROTECTION			

DEPARTMENT OF THE NAVY
NAVAL FACILITIES ENGINEERING COMMAND
NAVAL STATION - NORFOLK, VIRGINIA
GROTON, CT
SUBBASE NEW LONDON
BLDG. 484 - NEX MAIN STORE EXPANSION & RENOVATION
PHASING PLAN - PHASE 4

SCALE:	GRAPHIC
EPROJECT NO.	1305708
CONSTR. CONTR. NO.	N40085-14-C-5203
NAVFAC DRAWING NO.	12667650
SHEET	6 OF 236

G-006

1

2


3

4


5

1 2 3 4 5

D
C
B
A

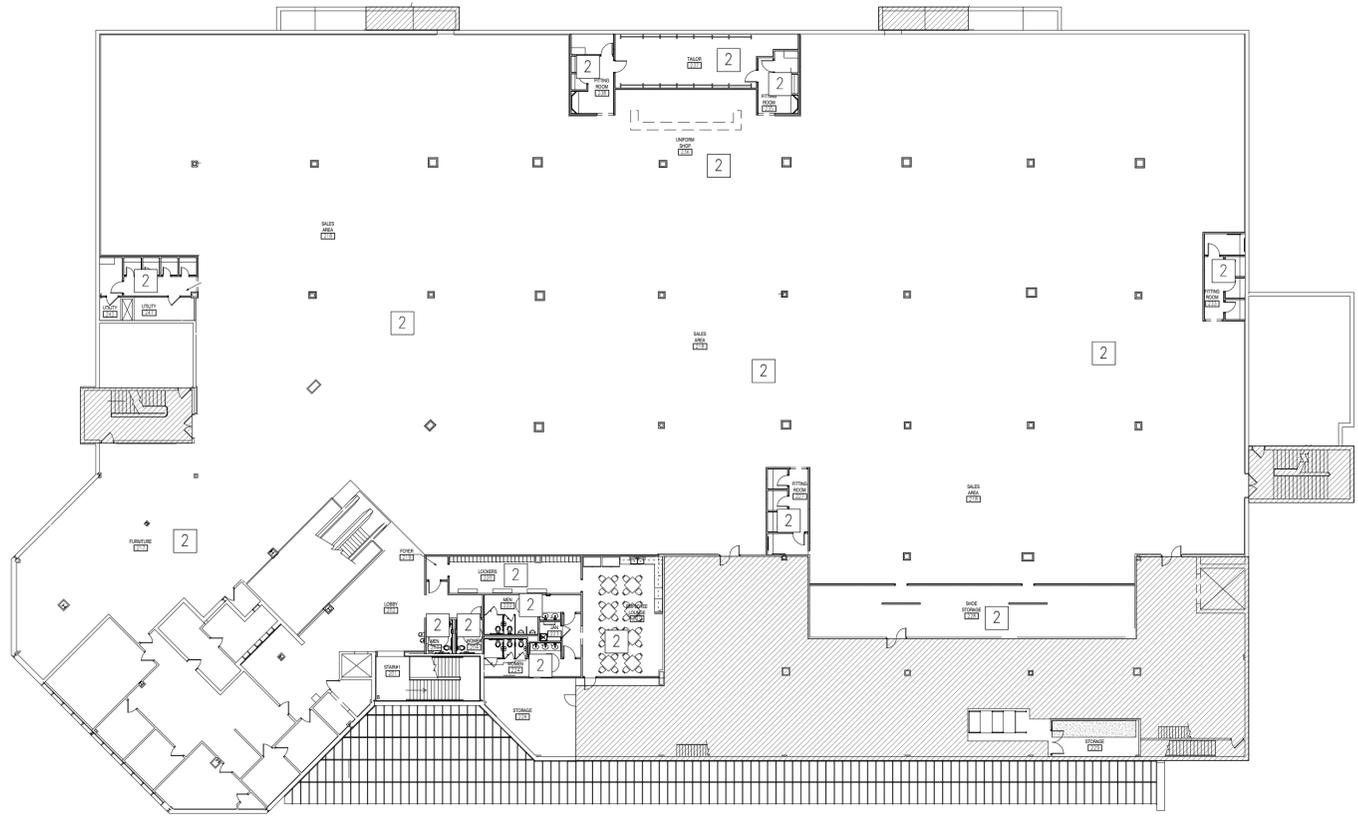

PHASE 5 - SECOND FLOOR
NOT TO SCALE

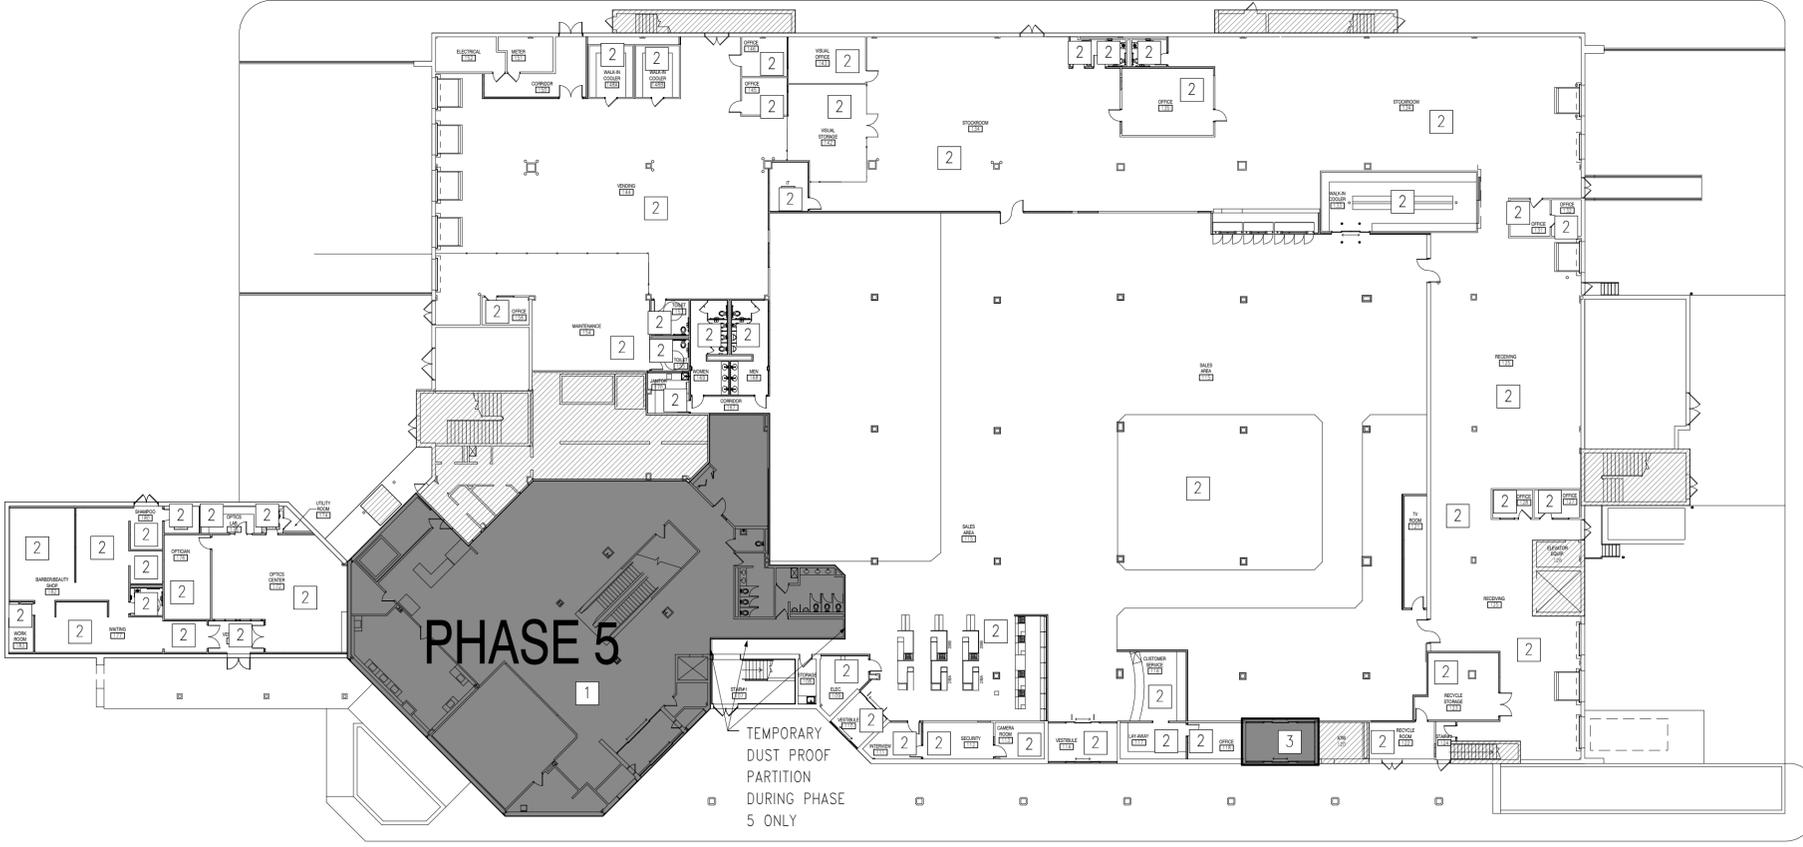

PHASE 5 - FIRST FLOOR
NOT TO SCALE



GENERAL PHASING NOTES

 
1. NEX WILL OCCUPY SPACES IN THE BUILDING IMMEDIATELY ADJACENT TO AREAS TO BE DEMOLISHED AND RENOVATED, DURING ALL PHASES. PROVIDE TEMPORARY DUSTPROOF BARRIERS BETWEEN PORTIONS OF THE WORK INCLUDED IN EACH PHASE, AND THE ADJACENT AREAS OCCUPIED BY NEX. CONDUCT SELECTIVE DEMOLITION SO NEX'S OPERATIONS WILL NOT BE DISTURBED.
2. PERFORM SELECTIVE DEMOLITION IN A MANNER AND USING EQUIPMENT THAT WILL MINIMIZE NOISE AND VIBRATIONS IN THE EXISTING BUILDING, INCLUDING BUT NOT LIMITED TO PROPER SHORING AND SEPARATION.
3. EXISTING UTILITIES TO PORTIONS OF THE BUILDING OCCUPIED BY NEX MUST REMAIN IN CONTINUOUS UNINTERRUPTED SERVICE DURING THE HOURS OF OPERATION FOR THE NEX. COORDINATE WITH THE GOVERNMENT ANY TEMPORARY DISRUPTIONS IN SERVICE THAT MAY BE REQUIRED. ALL UTILITY OUTAGES EFFECTING THE OCCUPIED PORTION OF THE NEX WILL BE PLANNED AND EXECUTED AFTER NORMAL BUSINESS HOURS.
4. MAINTAIN BUILDING OCCUPANT LIFE SAFETY PER NFPA 101 THROUGHOUT ENTIRE CONSTRUCTION DURATION. PROVIDE CODE COMPLIANT LIFE SAFETY EGRESS PATHWAYS. THESE PATHWAYS SHALL BE KEPT CLEAR AND FREE OF DEBRIS AT ALL TIMES. SAFE CUSTOMER ACCESS MUST BE MAINTAINED AT ALL TIMES.
5. THE BUILDING ENVELOPE WILL NOT BE COMPROMISED DURING ANY PHASE OF CONSTRUCTION. MAINTAIN A CONTINUOUSLY WEATHERTIGHT AND PROPERLY SEALED CONDITION THROUGHOUT ALL PHASES OF CONSTRUCTION.
6. PROVIDE TEMPORARY ENCLOSURE AS REQUIRED TO MAINTAIN EXISTING BUILDING IN A WEATHERTIGHT CONDITION AND TO PROTECT EXISTING FINISHES TO REMAIN. PRIOR TO BEGINNING WORK, PROTECT ALL WALLS, CEILINGS, FLOORS, AND OTHER EXISTING FINISH WORK THAT ARE TO REMAIN. MAINTAIN PROTECTION FOR THE ENTIRE DURATION OF THE WORK, AS NECESSARY TO PROTECT EXISTING WALLS, CEILINGS, FLOORS, AND OTHER EXISTING FINISH WORK.
7. DAMAGE CAUSED BY CONSTRUCTION OPERATIONS SHALL BE REPAIRED BY THE CONTRACTOR TO THE SATISFACTION OF THE CONTRACTING OFFICER AT NO ADDITIONAL COST TO THE GOVERNMENT.
8. EXISTING FURNITURE, FIXTURES, AND EQUIPMENT WILL BE MOVED, REMOVED, OR REPLACED BY NEX PRIOR TO THE START OF EACH PHASE. COORDINATE THE SCHEDULING OF PHASING AND PREPARATION REQUIREMENTS WITH THE CONTRACTING OFFICER.
9. CONTRACTOR SHALL COMPLY WITH ALL APPLICABLE FEDERAL RULES AND REGULATIONS GOVERNING WORKER SAFETY CLEARANCE, FACILITY ACCESS AND WORK IN THE FACILITY (COORDINATE THE DRAWING NOTE(S) WITH THE PROPER SPEC SECTION). THE CONTRACTOR WILL BE ALLOWED ACCESS ONLY TO THE PHASE UNDER CONSTRUCTION; OTHER BUILDING AREAS WILL BE RESTRICTED.
10. THE CONTRACTOR SHALL REVIEW ALL CONTRACT DOCUMENTS FOR FULL SCOPE OF PHASING COORDINATION AND PHASING PLAN REQUIREMENTS. PHASED WORK SHALL PROCEED IN NUMERICAL SEQUENCE.
11. DEVELOP AND SUBMIT A DETAILED CONSTRUCTION PHASING PLAN FOR REVIEW AND APPROVAL PER SPECIFICATION SECTION 01 14 00 WORK RESTRICTIONS. THE PLAN SHALL ENCOMPASS HAZMAT ABATEMENT, DEMOLITION AND NEW WORK. AS PART OF THE PHASING PLAN SUBMITTAL, THE CONTRACTOR SHALL IDENTIFY LIFE SAFETY EGRESS PATHWAYS. IN ADDITION, IDENTIFY NEX, CUSTOMER AND CONTRACTOR ENTRANCES AND EXITS. DEVELOP AND SUBMIT A "WORK AREA SCHEDULE" AS PART OF, OR AS AN APPENDIX, TO THE PHASING PLAN. THE SCHEDULE SHOULD BE BROKEN DOWN BY PHASE AND DETAIL AREAS OF HAZMAT ABATEMENT, DEMOLITION AND NEW WORK.
12. WORK ON THE CURRENT PHASE MUST BE COMPLETED (NEW SYSTEMS TESTED AND OPERATIONAL, SPACES CLEANED READY FOR OCCUPANCY) BEFORE THE CONTRACTOR WILL BE PERMITTED TO BEGIN WORK ON THE NEXT PHASE. THE CURRENT PHASE SHALL BE CERTIFIED HAZMAT-FREE BEFORE THE CONTRACTOR WILL BE ALLOWED TO PERFORM ADDITIONAL WORK ON THAT PHASE.
13. AIR DISTRIBUTION SYSTEMS SERVING THE SEPARATE PHASES MUST BE KEPT SEPARATE AT ALL TIMES TO PREVENT THE MIGRATION OF HAZMAT AND DUST TO UN-RENOVATED SPACES. ENSURE THAT ALL BUILDING ACCESS POINTS FROM MECHANICAL SHAFTS AND WALL PENETRATIONS ARE SECURED, EXCEPT AT SUCH POINTS AS ARE REQUIRED TO PERFORM WORK ON THE CURRENT PHASE OF THE PROJECT.

PHASE 5 KEY NOTES:

THIS SHEET ONLY

1. PERFORM SELECTIVE DEMOLITION AND RENOVATIONS IN THE AREA DESIGNATED.
2. PORTIONS OF THE BUILDING RENOVATED IN PRIOR PHASES WILL BE OCCUPIED BY THE NEX AS THEY BECOME AVAILABLE.
3. EXISTING VESTIBULE AND AUTOMATIC SLIDING GLASS DOORS SHALL REMAIN IN OPERATION UNTIL THE REMAINDER OF PHASE 5 WORK IS COMPLETED IN ORDER TO MAINTAIN REMOTE DISTANCE OF EXIT REQUIREMENTS PER CODE. THE EXISTING AUTOMATIC SLIDING GLASS SHALL THEN BE REMOVED AND THE VESTIBULE SHALL BE CONVERTED TO OFFICE 119 AS DESIGNED.

PHASING LEGEND:



APPR.	DATE
DESCRIPTION	DATE
  	
APPROVED FOR COMMANDER NAVFAC ACTIVITY: CDR MARC BERNATH NEXCOM - FACILITIES DIVISION SATISFACTORY TO DATE: 07JUL2014 DES. JB DRW. JT CHK. DE PM/DW: RDS/PJB BRANCH MANAGER CHIEF ENCL/ARCH: DWG FIRE PROTECTION	
DEPARTMENT OF THE NAVY NAVAL FACILITIES ENGINEERING COMMAND NAVAL STATION - NORFOLK, VIRGINIA GROTON, CT SUBBASE NEW LONDON BLDG. 484 - NEX MAIN STORE EXPANSION & RENOVATION PHASING PLAN - PHASE 5	
SCALE: GRAPHIC	PROJECT NO. 1305708
CONSTR. CONTR. NO. N40085-14-C-5203	NAVFAC DRAWING NO. 12667651
SHEET 7 OF 236	G-007